

Copyright of this drawing is vested in BPM Architectural and it must not be copied or reproduced without written consent. Figured dimensions only are to be taken from this drawing. DO NOT SCALE OFF THIS DRAWING. — If in DOUBT ASK.


All contractors must visit the site and be responsible for taking and checking all dimensions relative to their work. BPM Architectural are to be advised of any variation between drawings and site conditions.

Electronic data drawings issued as 'read only' and should not be interpreted for measurement. All dimensions and levels should be 'read only' from those values stated in text on the drawings.

KEY PLAN:

KEY TO SYMBOLS

- 6kw 6kw oven supply
- 13 amp double socket
- electrical switch over worktop with concealed socket under
- Lightswitch
- Exterior wall mounted LED movement sensor operated light
- Surface mounted LED downlight
- LED batten light under wall unit
- Shaving Point
- Wash hand basin in vanity unit with LED down lighter over back mirror operated by string pull cord
- CO2 fire extinguisher/ fire blanket mounted on wall brackets
- Television Point
- Control Panel (for Intruder Alarm)
- Smoke Detector
- Heat Detector
- Sounder
- Carbon monoxide Detector
- Emergency Lighting

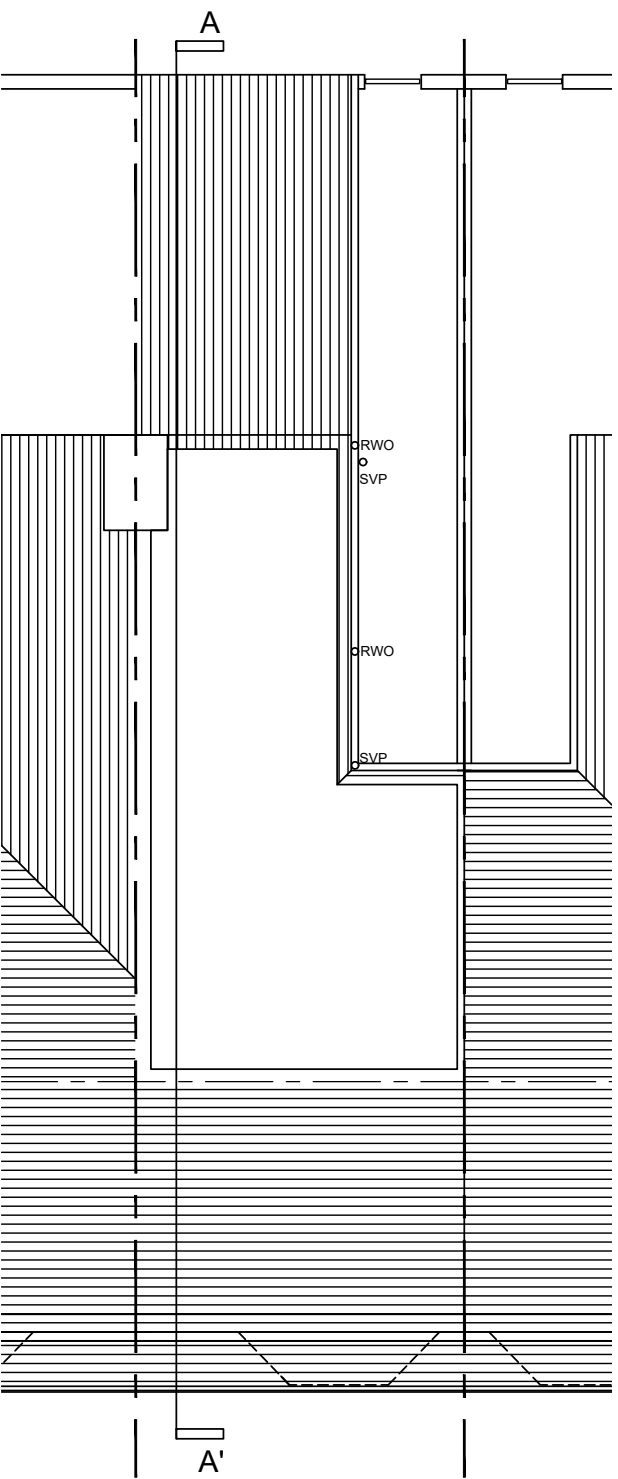

ROOF PLAN
1:100@A1

REV: DATE: DETAILS:

BM ARCHITECTURAL SERVICES
224 GREAT CLOWES STREET
MANCHESTER M7 2ZS
TEL: 07415 493002

PROJECT: DORMER LOFT CONVERSION AND REAR
SINGLE STOREY EXTENSION AT 161 ACOMB
STREET, RUSHOLME, MANCHESTER M14 4DY


TITLE: PROPOSED SITE PLAN AND PLANS

CLIENT: MR. DAVID HALL

SCALE: 1:50 @A1 DATE: 03/ 2026 DRAWN: BM


STATUS: BUILDING REGULATIONS

DRAWING No: BM/0326/ACOMB/BR3 REV:

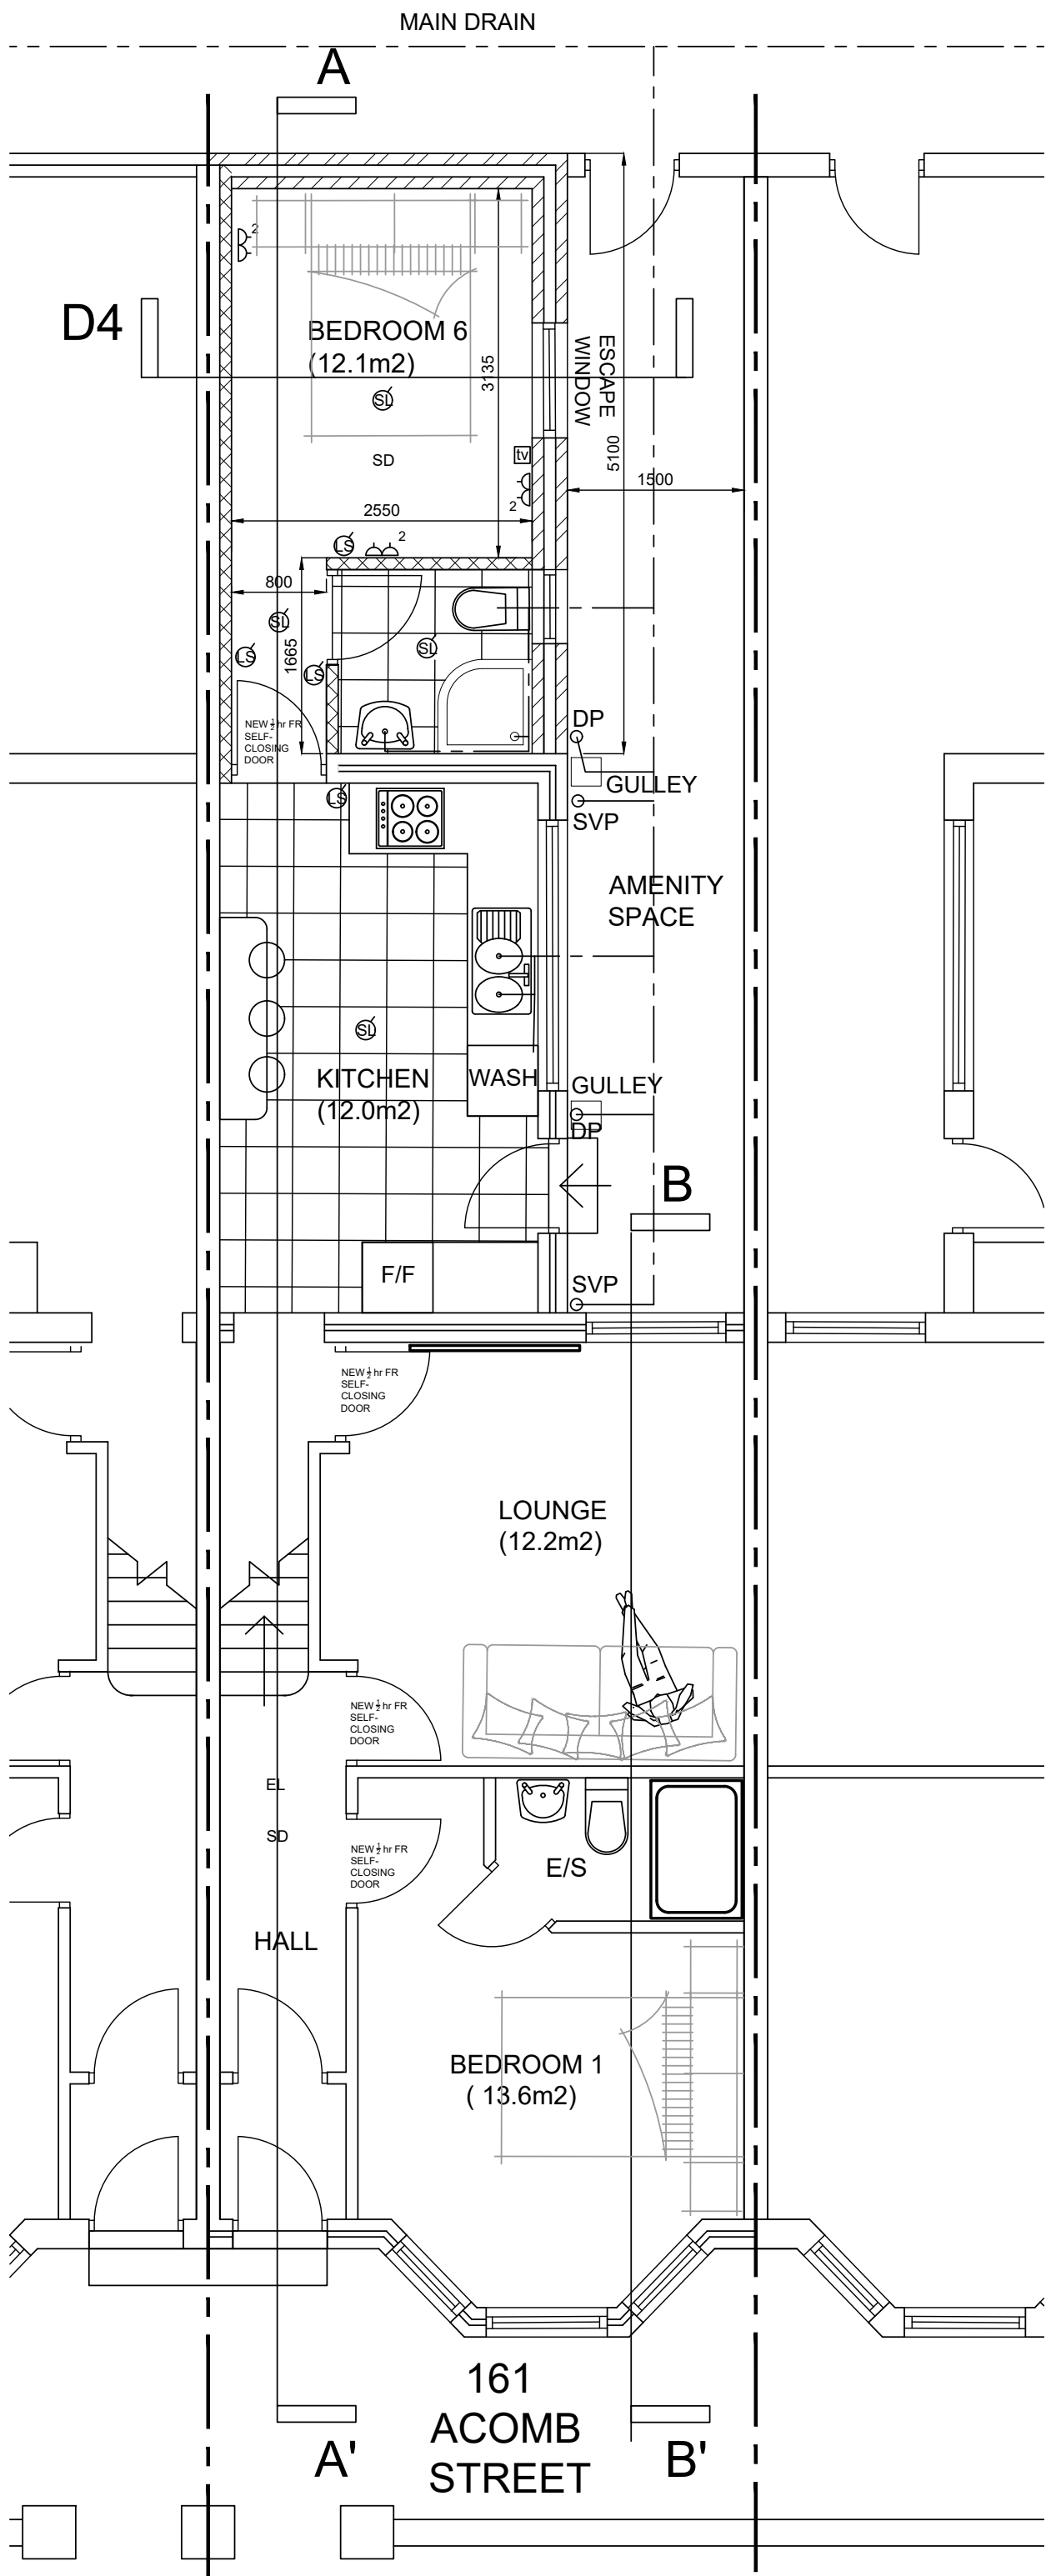


GROUND FLOOR PLAN

0 5 metres

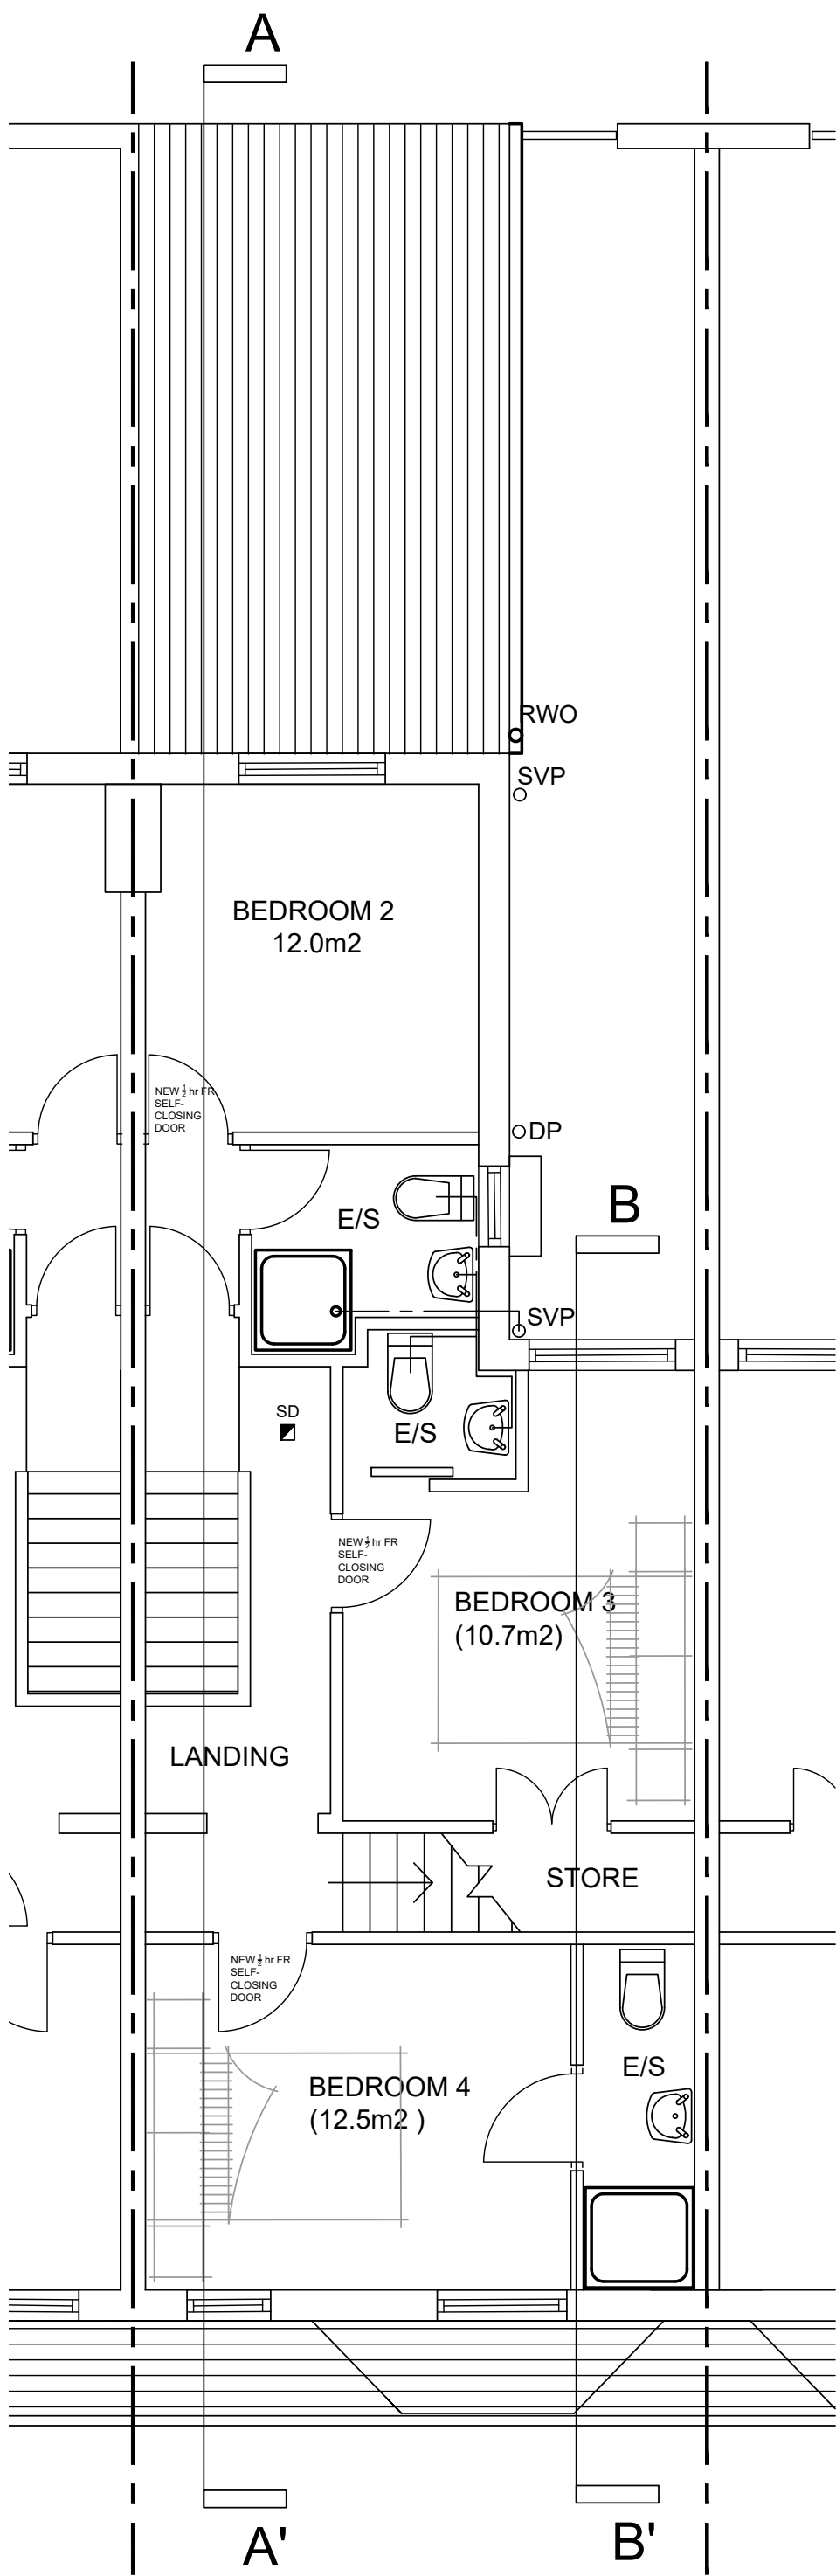

FIRST FLOOR PLAN

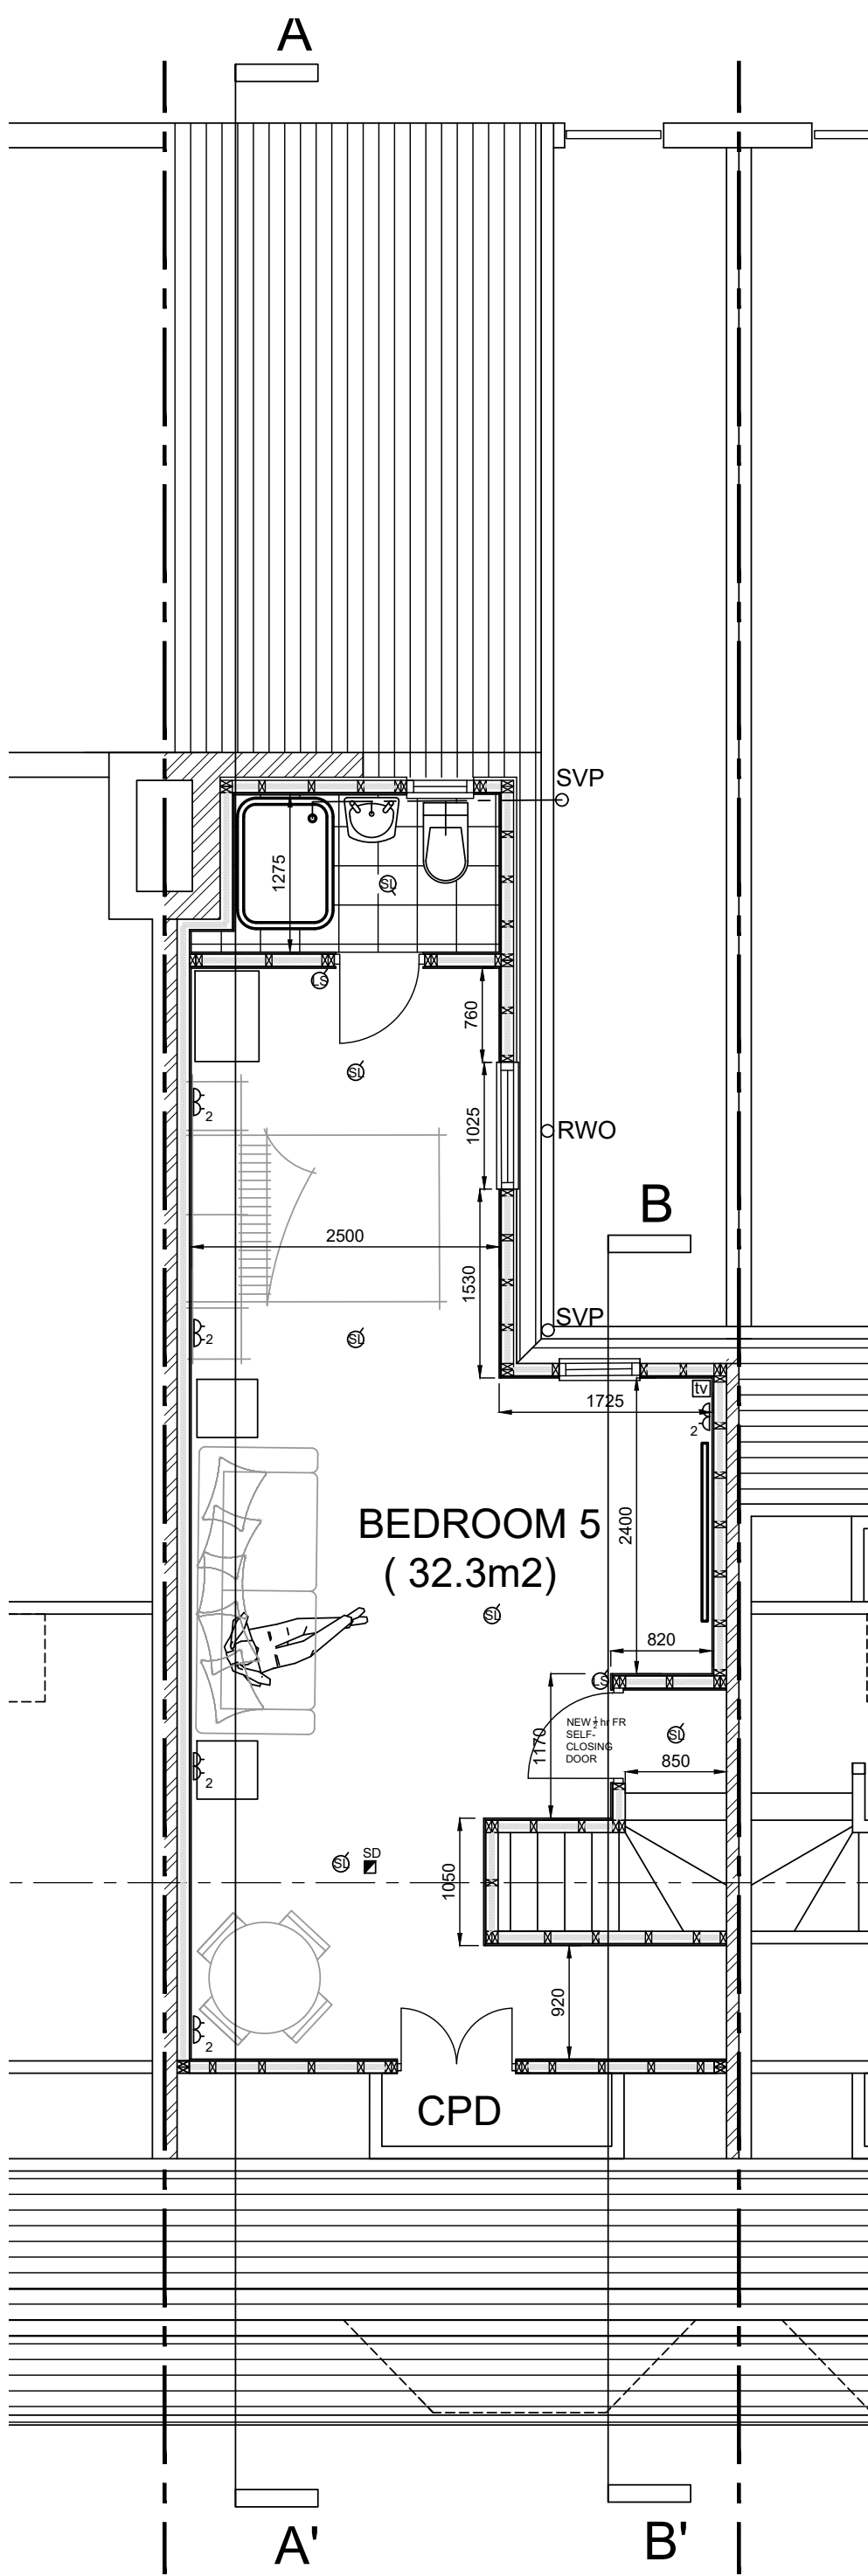

SECOND FLOOR PLAN