
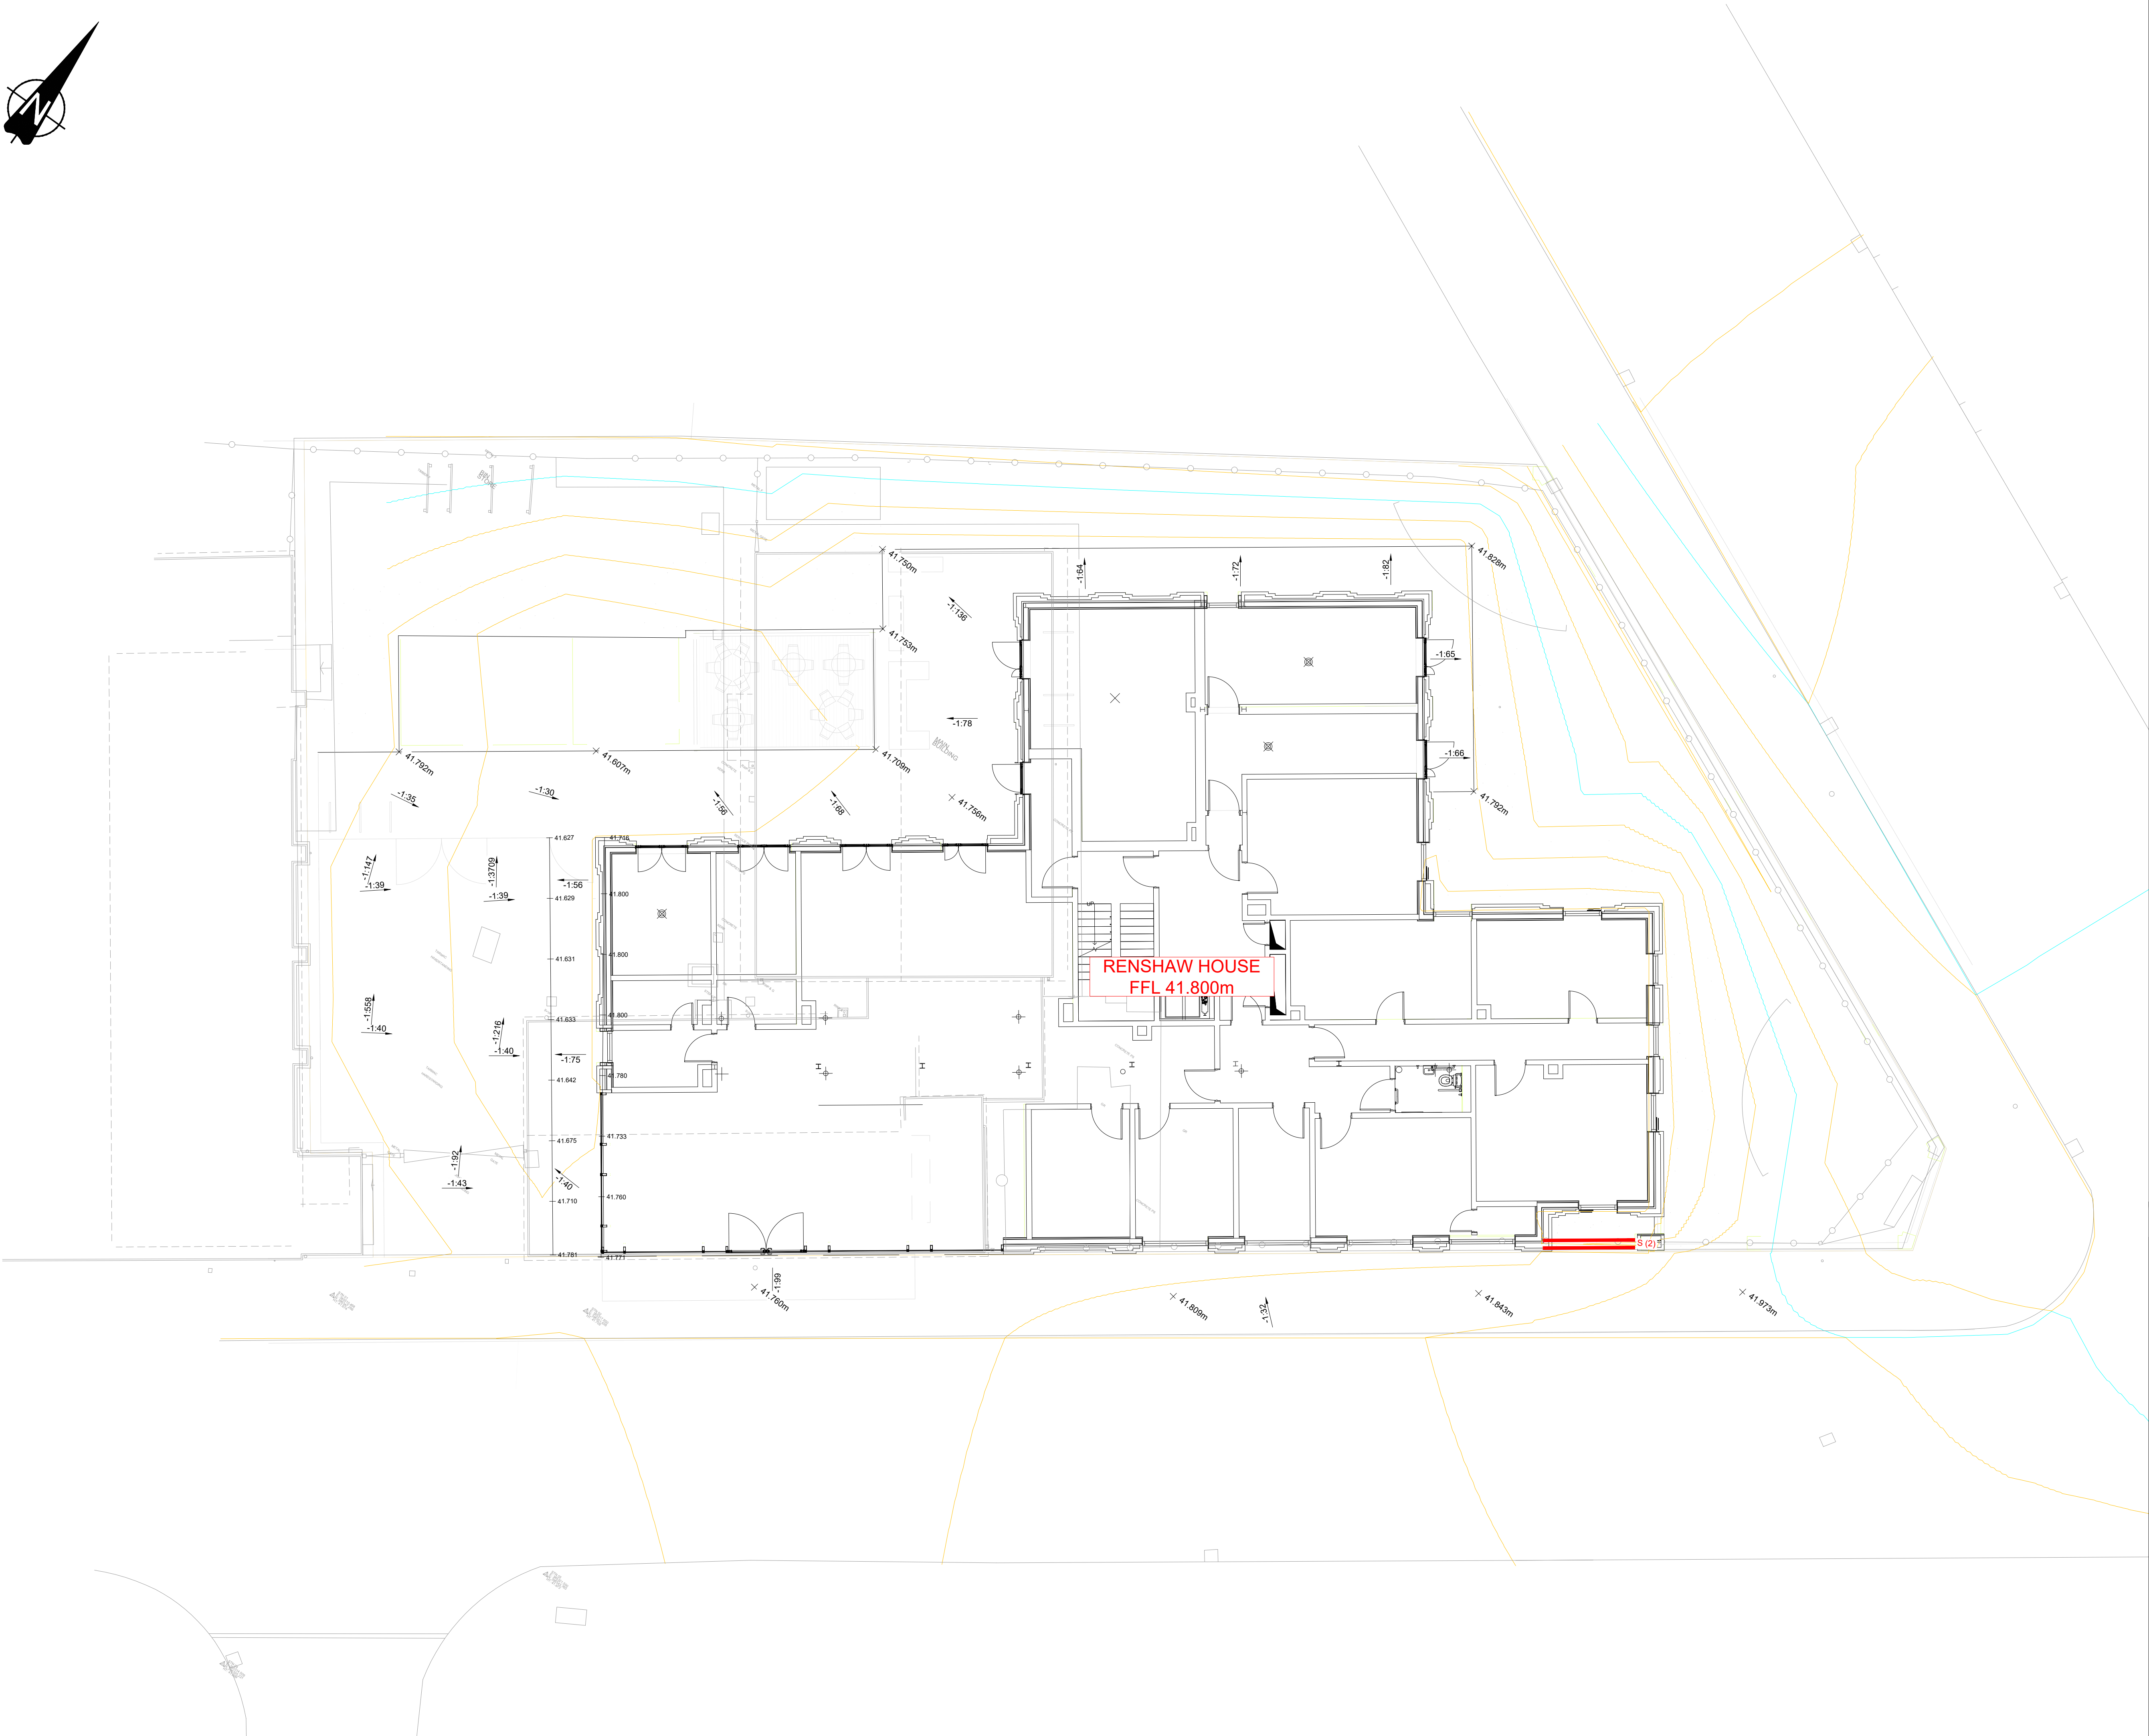


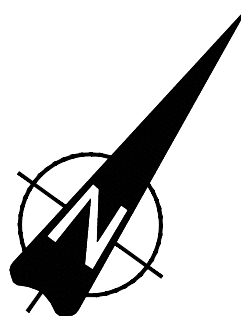

LEGEND	
—	MAJOR CONTOUR (0.5m INTERVALS)
—	MINOR CONTOUR (0.1m INTERVALS)
142.123m ×	PROPOSED SPOT LEVELS
1:20	PROPOSED LANDSCAPE GRADIENT
—	PROPOSED STEP INC. NUMBER OF STEPS

- NOTES**
- REFER TO ARCHITECTS DRAWINGS FOR CONFIRMATION OF LANDSCAPING ARRANGEMENTS.
- DRAWING INFORMATION**
- EXISTING SITE INFORMATION BASED ON TOPOGRAPHICAL SURVEY DATED 11/02/2025 PROVIDED BY GWPA ARCHITECTS LTD. DRAWING NO. 2337-GWP-01-00-D-A-(PA)-0002. ALL LEVELS SHOWN ARE IN METERS ABOVE ORDNANCE DATUM.
 - PROPOSED SITE LAYOUT BASED ON PROPOSED SITE PLAN DRAWING BY GWPA ARCHITECTS LTD. DRAWING NO. 2337-GWP-01-00-D-A-(PA)-0008.

- GENERAL NOTES:**
- THIS DRAWING IS BASED ON ORDNANCE SURVEY AND TOPOGRAPHICAL SURVEY INFORMATION RECEIVED. WE CAN ACCEPT NO LIABILITY FOR DESIGN BASED ON INFORMATION RECEIVED.
 - THIS DESIGN HAS BEEN CARRIED OUT TO APPROPRIATE STANDARDS BUT IT IS TO BE CHECKED IN ACCORDANCE WITH PROCUREMENT AND REQUIREMENTS PRIOR TO THE COMMENCEMENT OF WORKS.
 - ALL LEVELS, DIMENSIONS AND DETAILS TO BE CONFIRMED BY THE CONTRACTOR PRIOR TO THE COMMENCEMENT OF CONSTRUCTION OR FABRICATION.
 - GREASE TRAP REQUIREMENTS, ASSOCIATED FITTINGS AND INSTALLATION, WHETHER BURIED OR ABOVE GROUND, TO M&E CONTRACTOR'S DESIGN / DETAIL. M&E CONTRACTOR TO CONFIRM GREASE TRAP PROPOSALS PRIOR TO COMMENCEMENT OF DRAINAGE WORKS.
 - ALL RWPS AND SVPS TO BE FITTED WITH RODDABLE ACCESS PLATES. ALL DRAINS TO HAVE RODDABLE ACCESS.
 - ALL FOUL CONNECTIONS TO BE VENTED TO ATMOSPHERE. ALL POP-UPS LOCATED AT THE HEAD OF DRAINS TO BE VENTED ABOVE GROUND. ABOVE GROUND DRAINAGE DETAILS TO BE CONFIRMED BY THE M&E CONTRACTOR.
 - NO EXISTING SERVICES INFORMATION HAVE BEEN PROVIDED. THEREFORE, ALL INFORMATION IS TO BE VERIFIED FURTHER TO ANY SITE WORKS.
 - EXISTING GROUND LEVELS AND GROUND PROFILES HAVE BEEN TAKEN FROM THE INFORMATION PROVIDED AND AS SUCH ARE TO BE VERIFIED BY THE CONTRACTOR PRIOR TO THE COMMENCEMENT OF WORKS. ANY DISCREPANCIES TO BE BROUGHT TO THE ATTENTION OF THE ENGINEER.

C01	INFORMATION ISSUE	AT	AS	27.03.26
REV	DESCRIPTION	DRAWN	CKD	DATE

DRAWING STATUS:

CONSTRUCTION

T. (0191) 491 4684
E. enquiries@jc-consulting.net
www.jc-consulting.net

JC CONSULTING

Unit 16, The Stottle Shed
Bakers Yard, Christon Road
Gosforth, Newcastle upon Tyne
NE3 1XD

© JC CONSULTING LTD.

Civil Engineering
Structural Engineering
Geo-Environmental Engineering

CLIENT:				
BDP CONSTRUCTION LTD.				
PROJECT:				
RENSHAW HOUSE MANCHESTER				
DRAWING TITLE:				
PROPOSED EXTERNAL LEVELS				
SCALE:	DRAWN:	CKD:	DATE:	
1:100	AT	AS	27.03.26	
JOB NUMBER:	DRAWING NUMBER:	REV:	SIZE:	
JCC26-007	C-DR-102	C01	A1	