


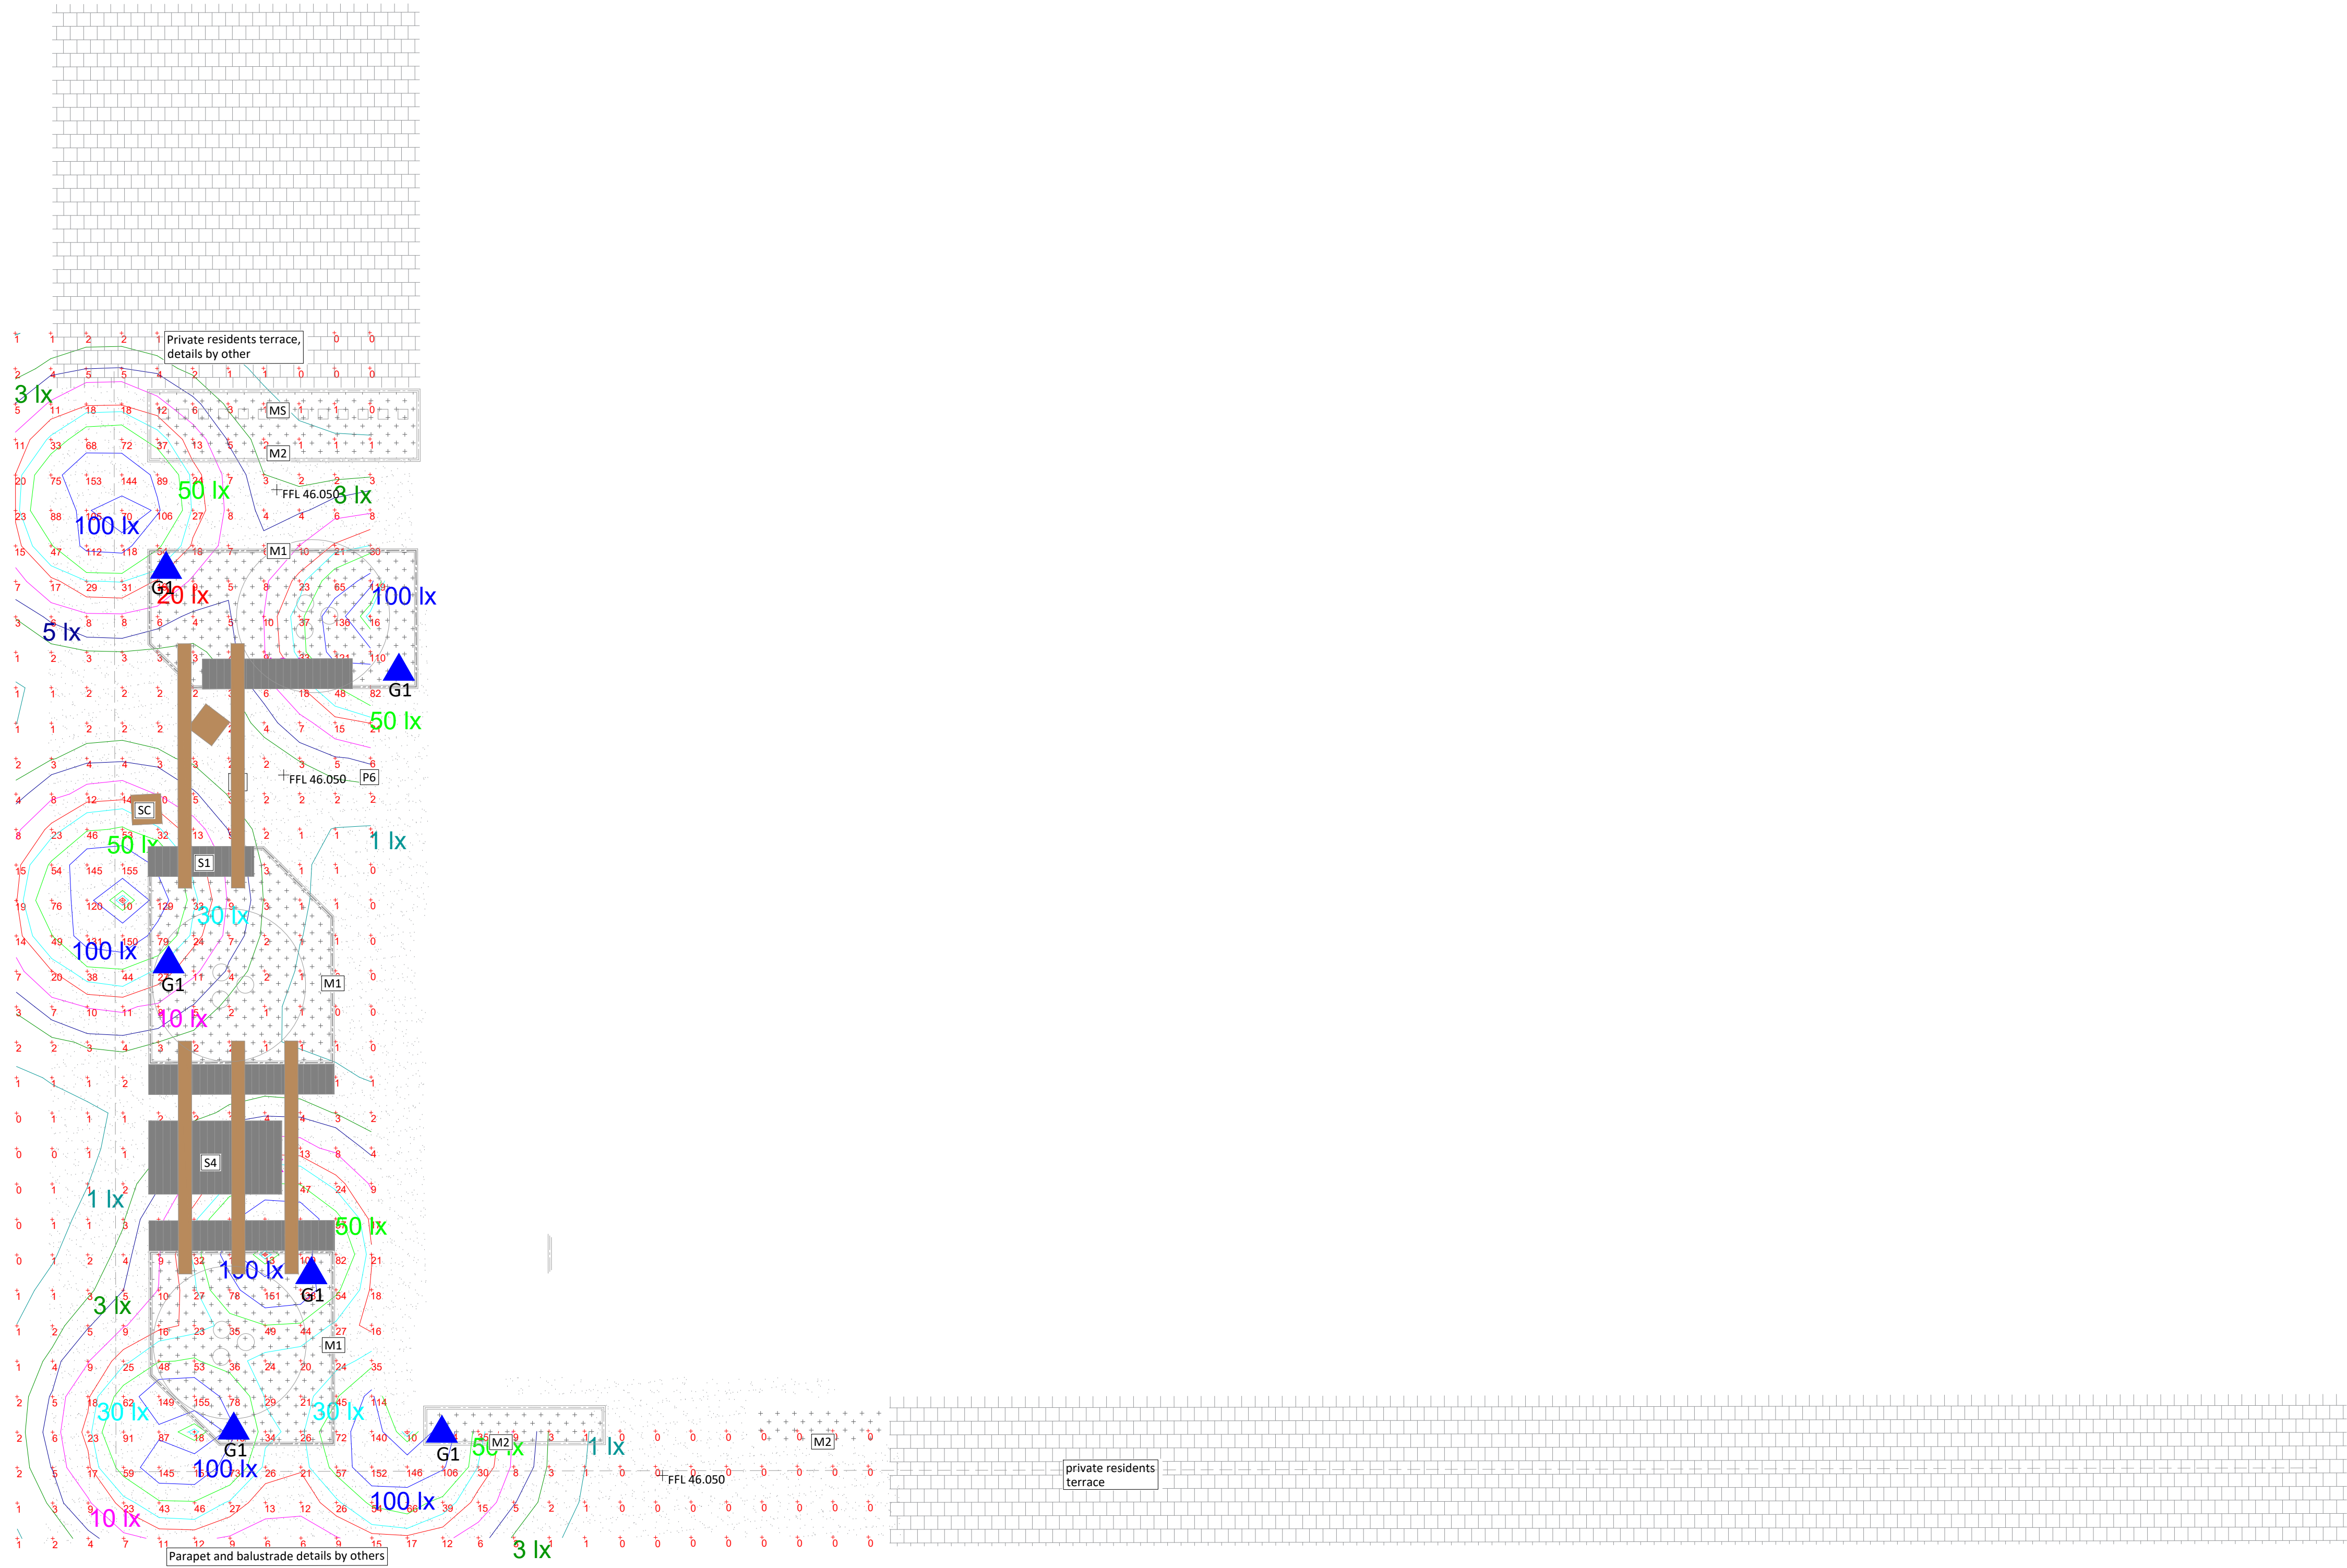

Calculation Summary							
Label	CalcType	Units	Avg	Max	Min	Uniformity(Min/Max)	Diversity (Min/Max)
Terrace	Illuminance	Lux	22.40	156	0	0.00	0.00

NOTES

THIS IS A DESIGN DRAWING NOT AN INSTALLATION DRAWING. DIMENSIONS SHOULD NOT BE SCALED. SITE DIMENSIONS TO BE CHECKED BEFORE PRODUCTION OF CRITICAL MANUFACTURING DRAWINGS. THE DRAWING IS COPYRIGHT AND NO PART MAY BE REPRODUCED WITHOUT WRITTEN CONSENT

LIGHTING LEGEND

A1

TIT055 SPIKE - REM-D-MEDIUM 25° OPTIC BY KINGFISHER (4W, IP68, 4000K)

B1

RAY180 SHORT - ULTRA WIDE FLOOD- 91° OPTIC CANOPY MOUNTED BY KINGFISHER (20W, IP68, 4000K)

C1

TOCCA 2.0-380mm - REM-D-FROSTED DIFFUSER 80° OPTIC, HANDRAIL MOUNTED BY KINGFISHER (4.2W, IP66, 2700K)

D1

SEMITA URBAN BULKHEAD - 250mA-ST STREET OPTIC BUILDING MOUNTED BY KINGFISHER (6W, IP66, 4000K)

D2

SEMITA URBAN BULKHEAD - 410mA-ST STREET OPTIC BUILDING MOUNTED BY KINGFISHER (11W, IP66, 4000K)

F1

CINEP - REM-D-1000mm-SIDE FLEX MOUNTED UNDER BENCH SEATING BY KINGFISHER (10W, IP66, 3000K)

G1

KLOU76 - BOLLARD LIGHTING, 715mm RADIAL OPTIC BY KINGFISHER (8W, IP66, 4000K)

H1

FEESTON LED LIGHTING SPECIFICATION AND MANUFACTURER TO BE CONFIRMED

/E

DENOTES EMERGENCY TYPE LUMINAIRE

Rev	FOR STAGE 3 APPROVAL			
P01	By: KO	Chkd: DH	Date: 21.01.26	App: AD
Status	Description	Stage		
S4	FOR APPROVAL	3		

Client

LINEAR GROUP

Project

1 LORD STREET MANCHESTER

Drawing

ELECTRICAL SERVICES
ROOF TERRACE LIGHTING LAYOUT

 TWENTY ONE
Tyneside | Teesside | Yorkshire | North West

Drawing Number		Revision
NO1LOR-CAD-90-RF-ZZ-DR-E-90201		P01
Scale	Size	
1:150	A1	
Drawing Origins		
--		
--		
--		