




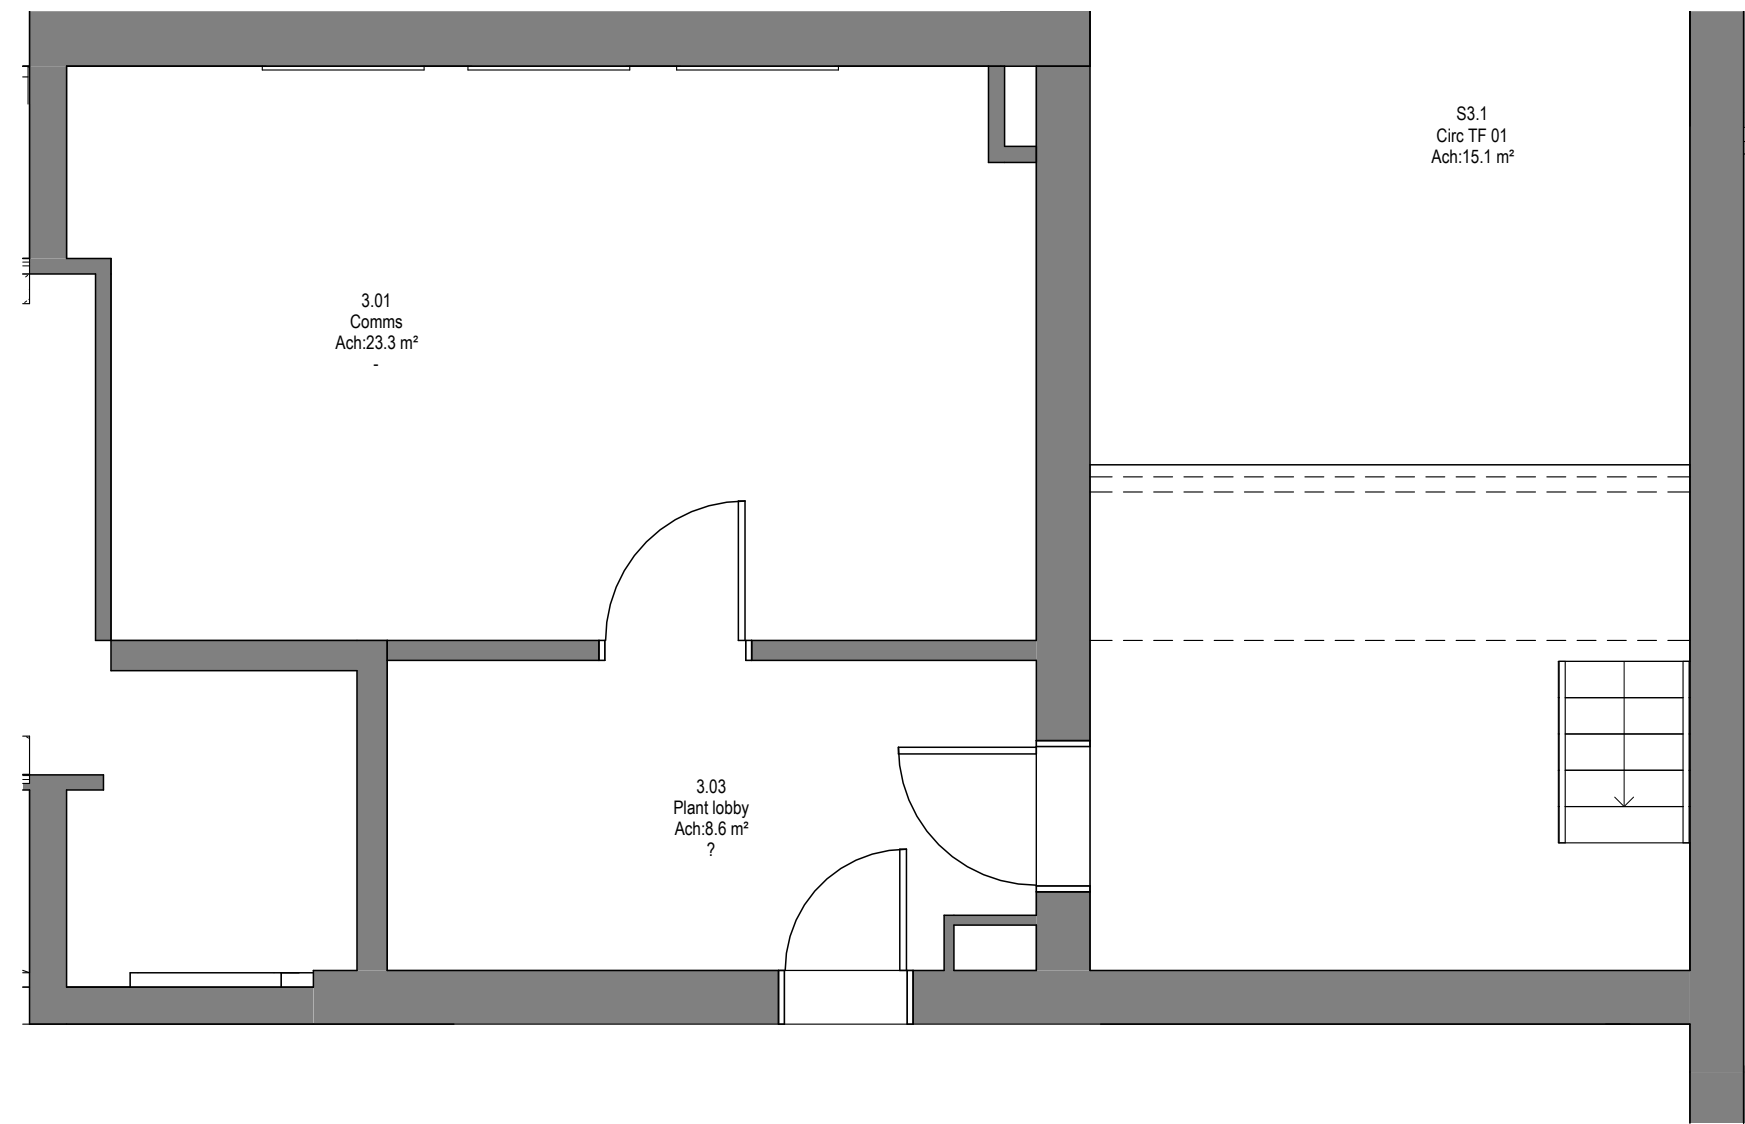


5 Proposed GA Plan Condenser unit - Level 03 Ceiling Plan_Existing
1 : 50

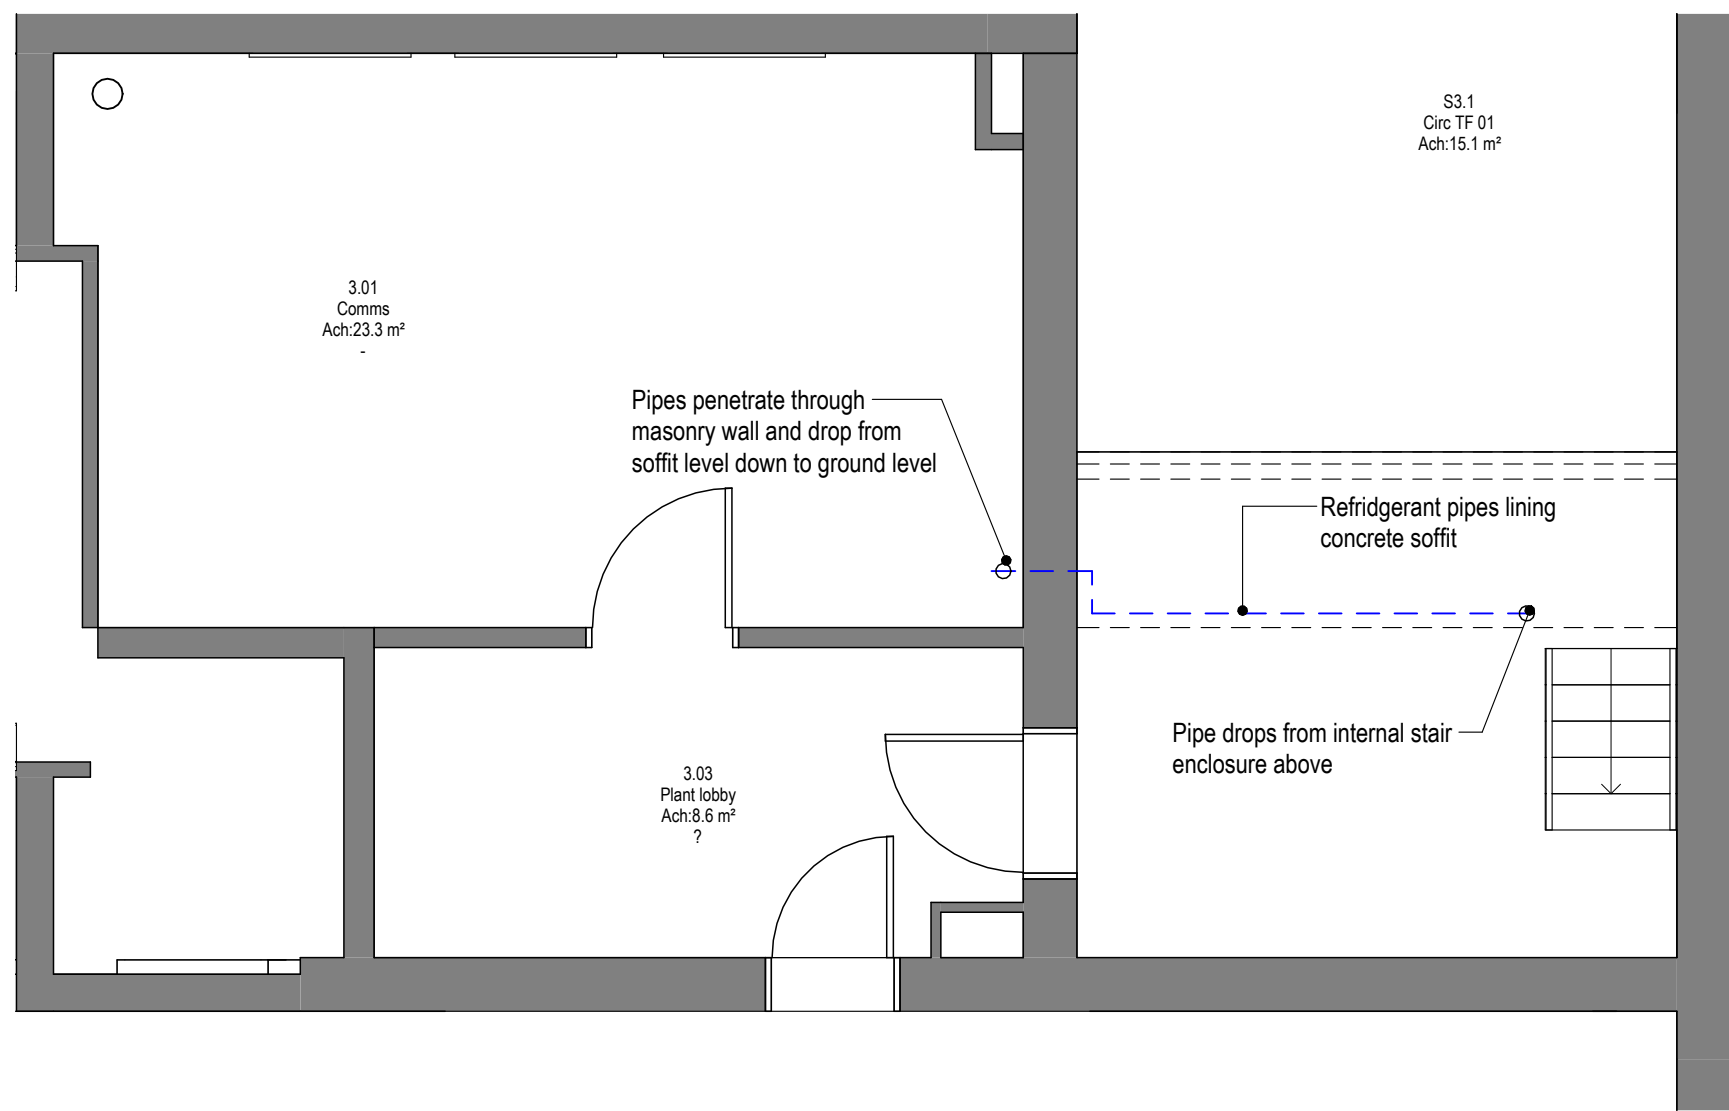


6 Proposed GA Plan Condenser unit - Level 03 Ceiling Plan_Proposed
1 : 50

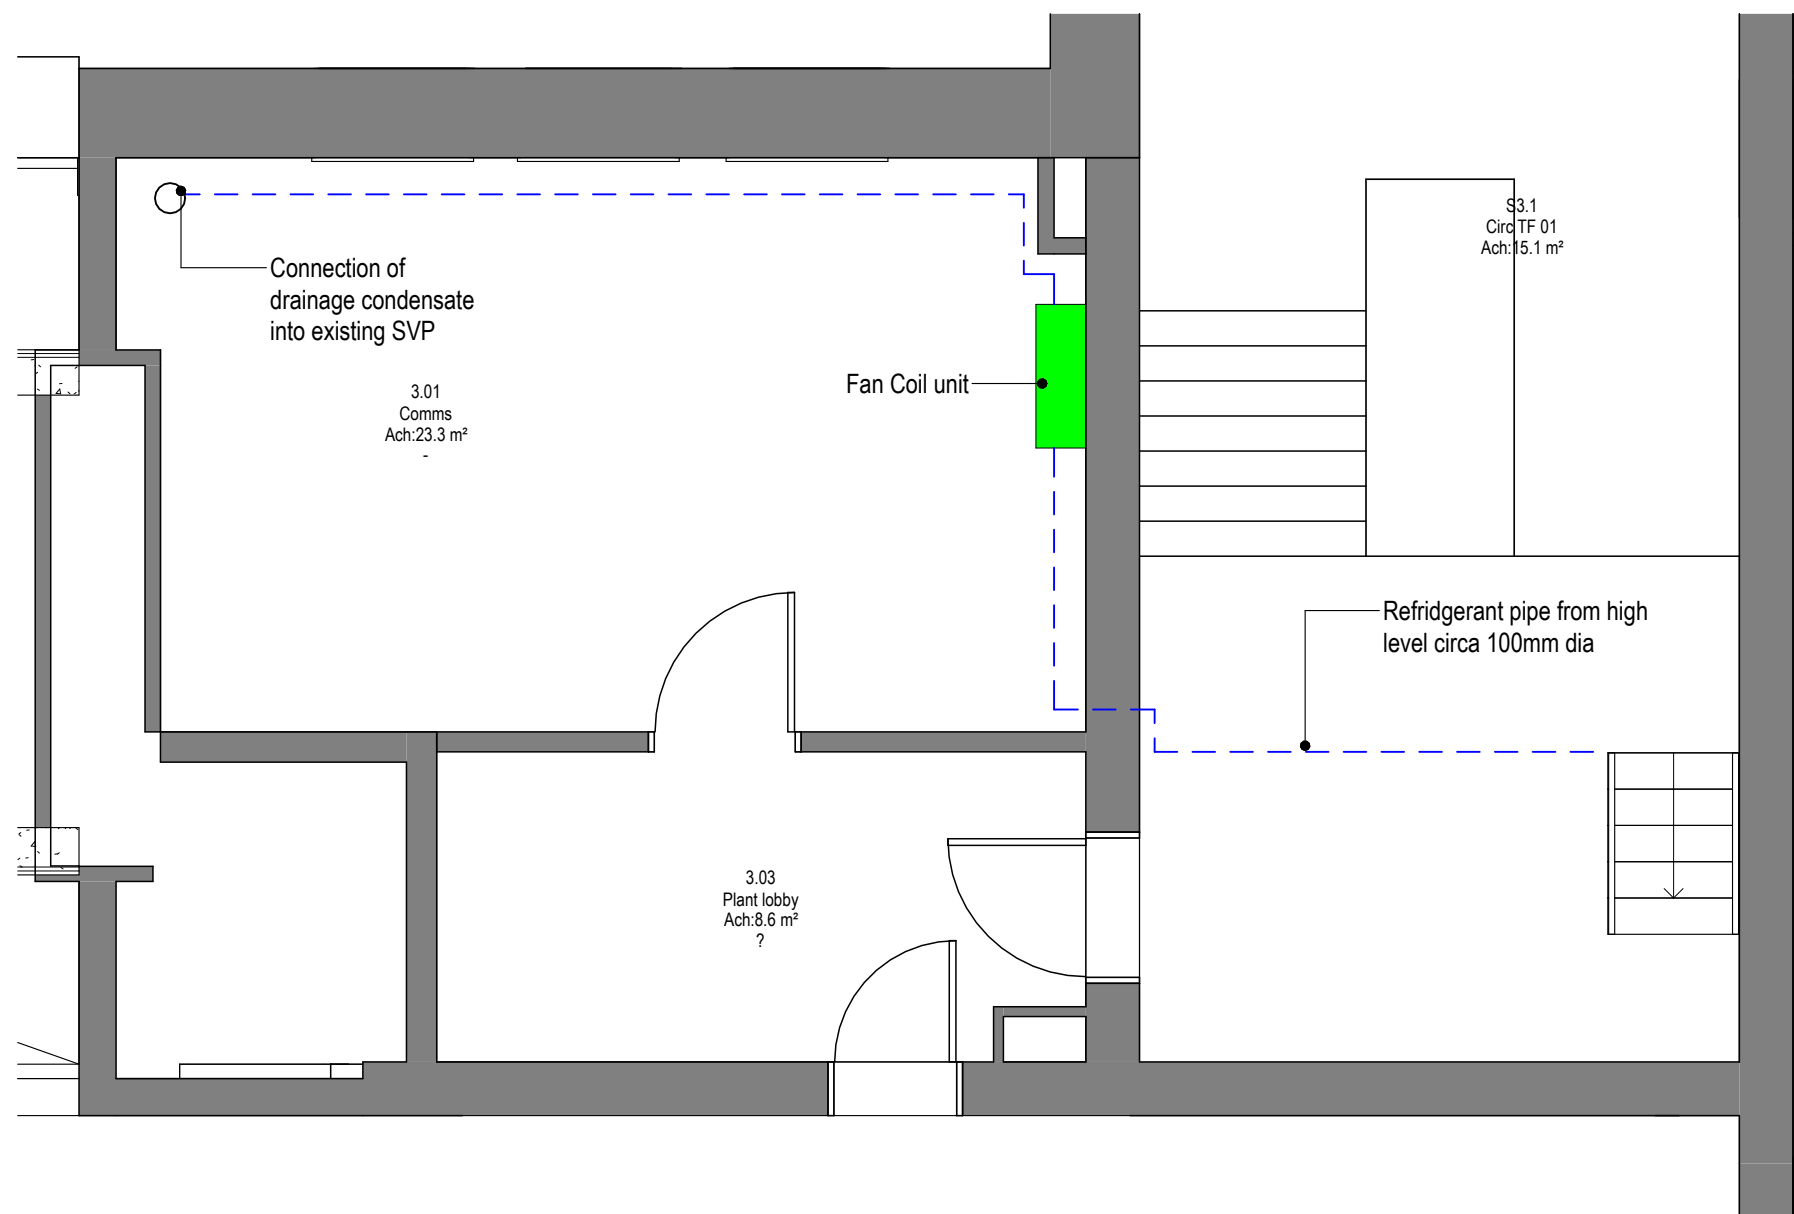


3 Proposed GA Plan Condenser unit - Level 03
1 : 50

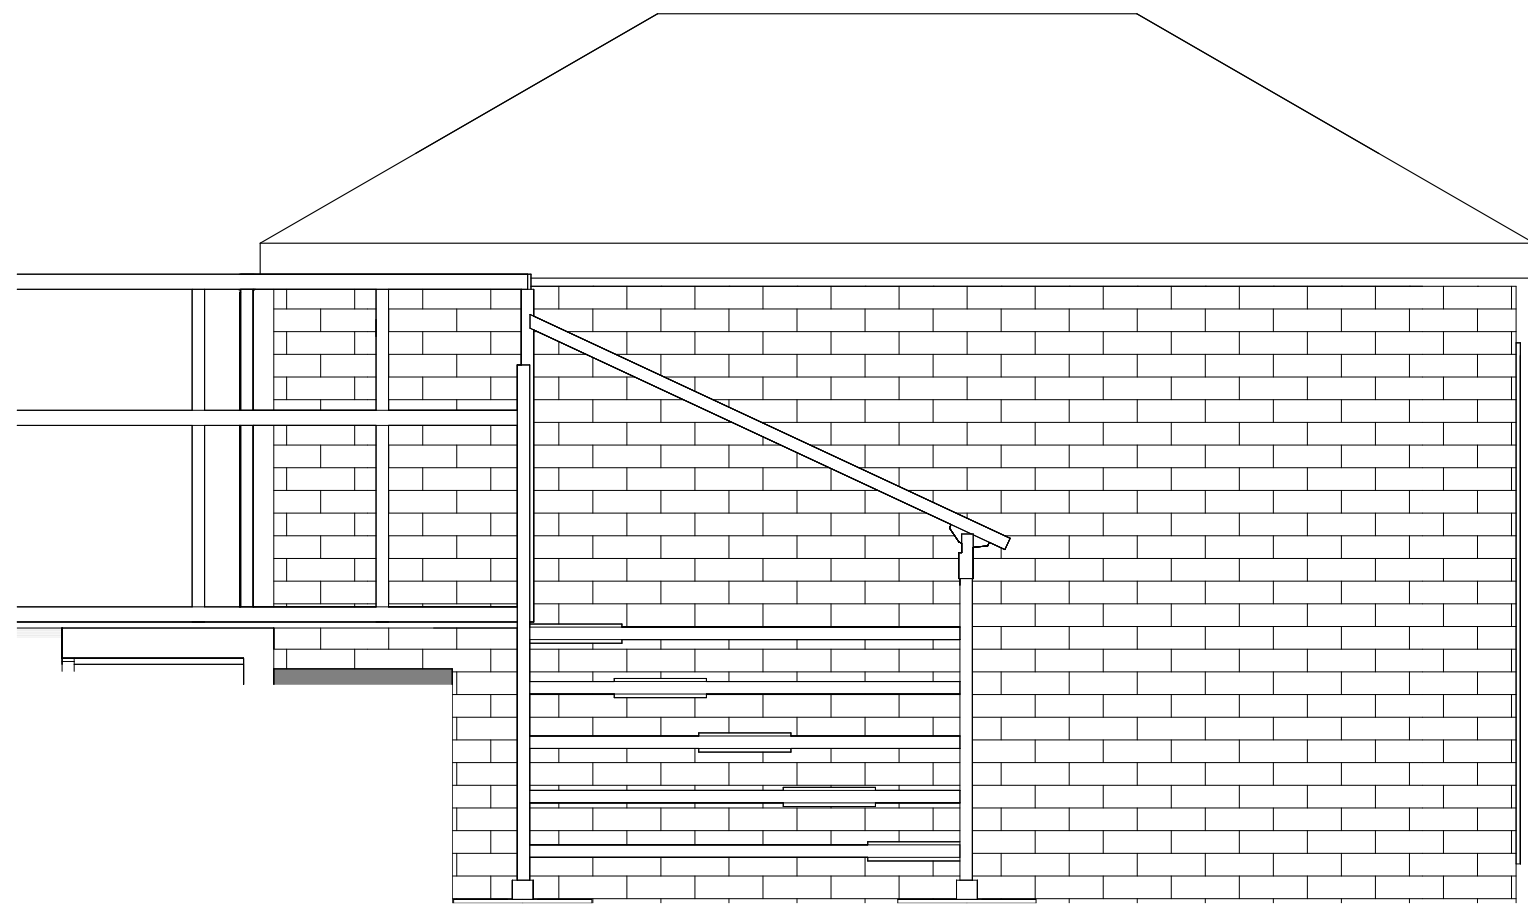

1 Condenser Unit on Roof D - Existing Elevation
1 : 25

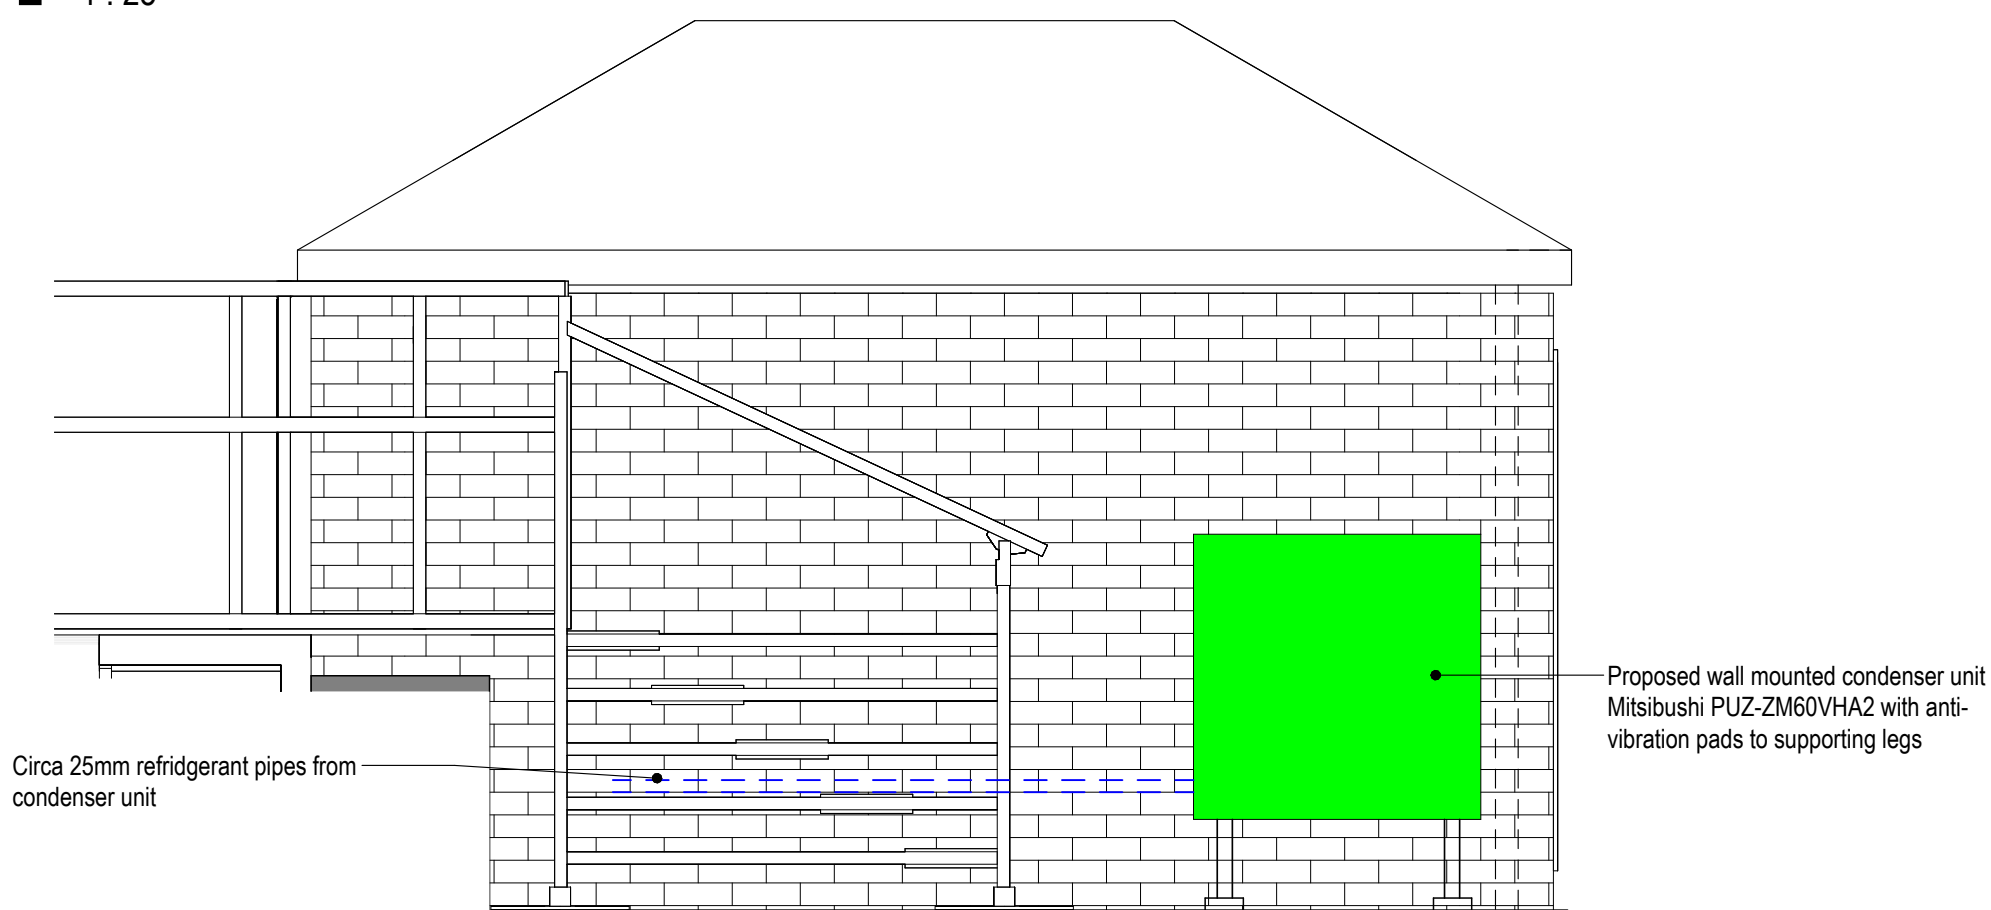

2 Condenser Unit on Roof D - Proposed Elevation
1 : 25

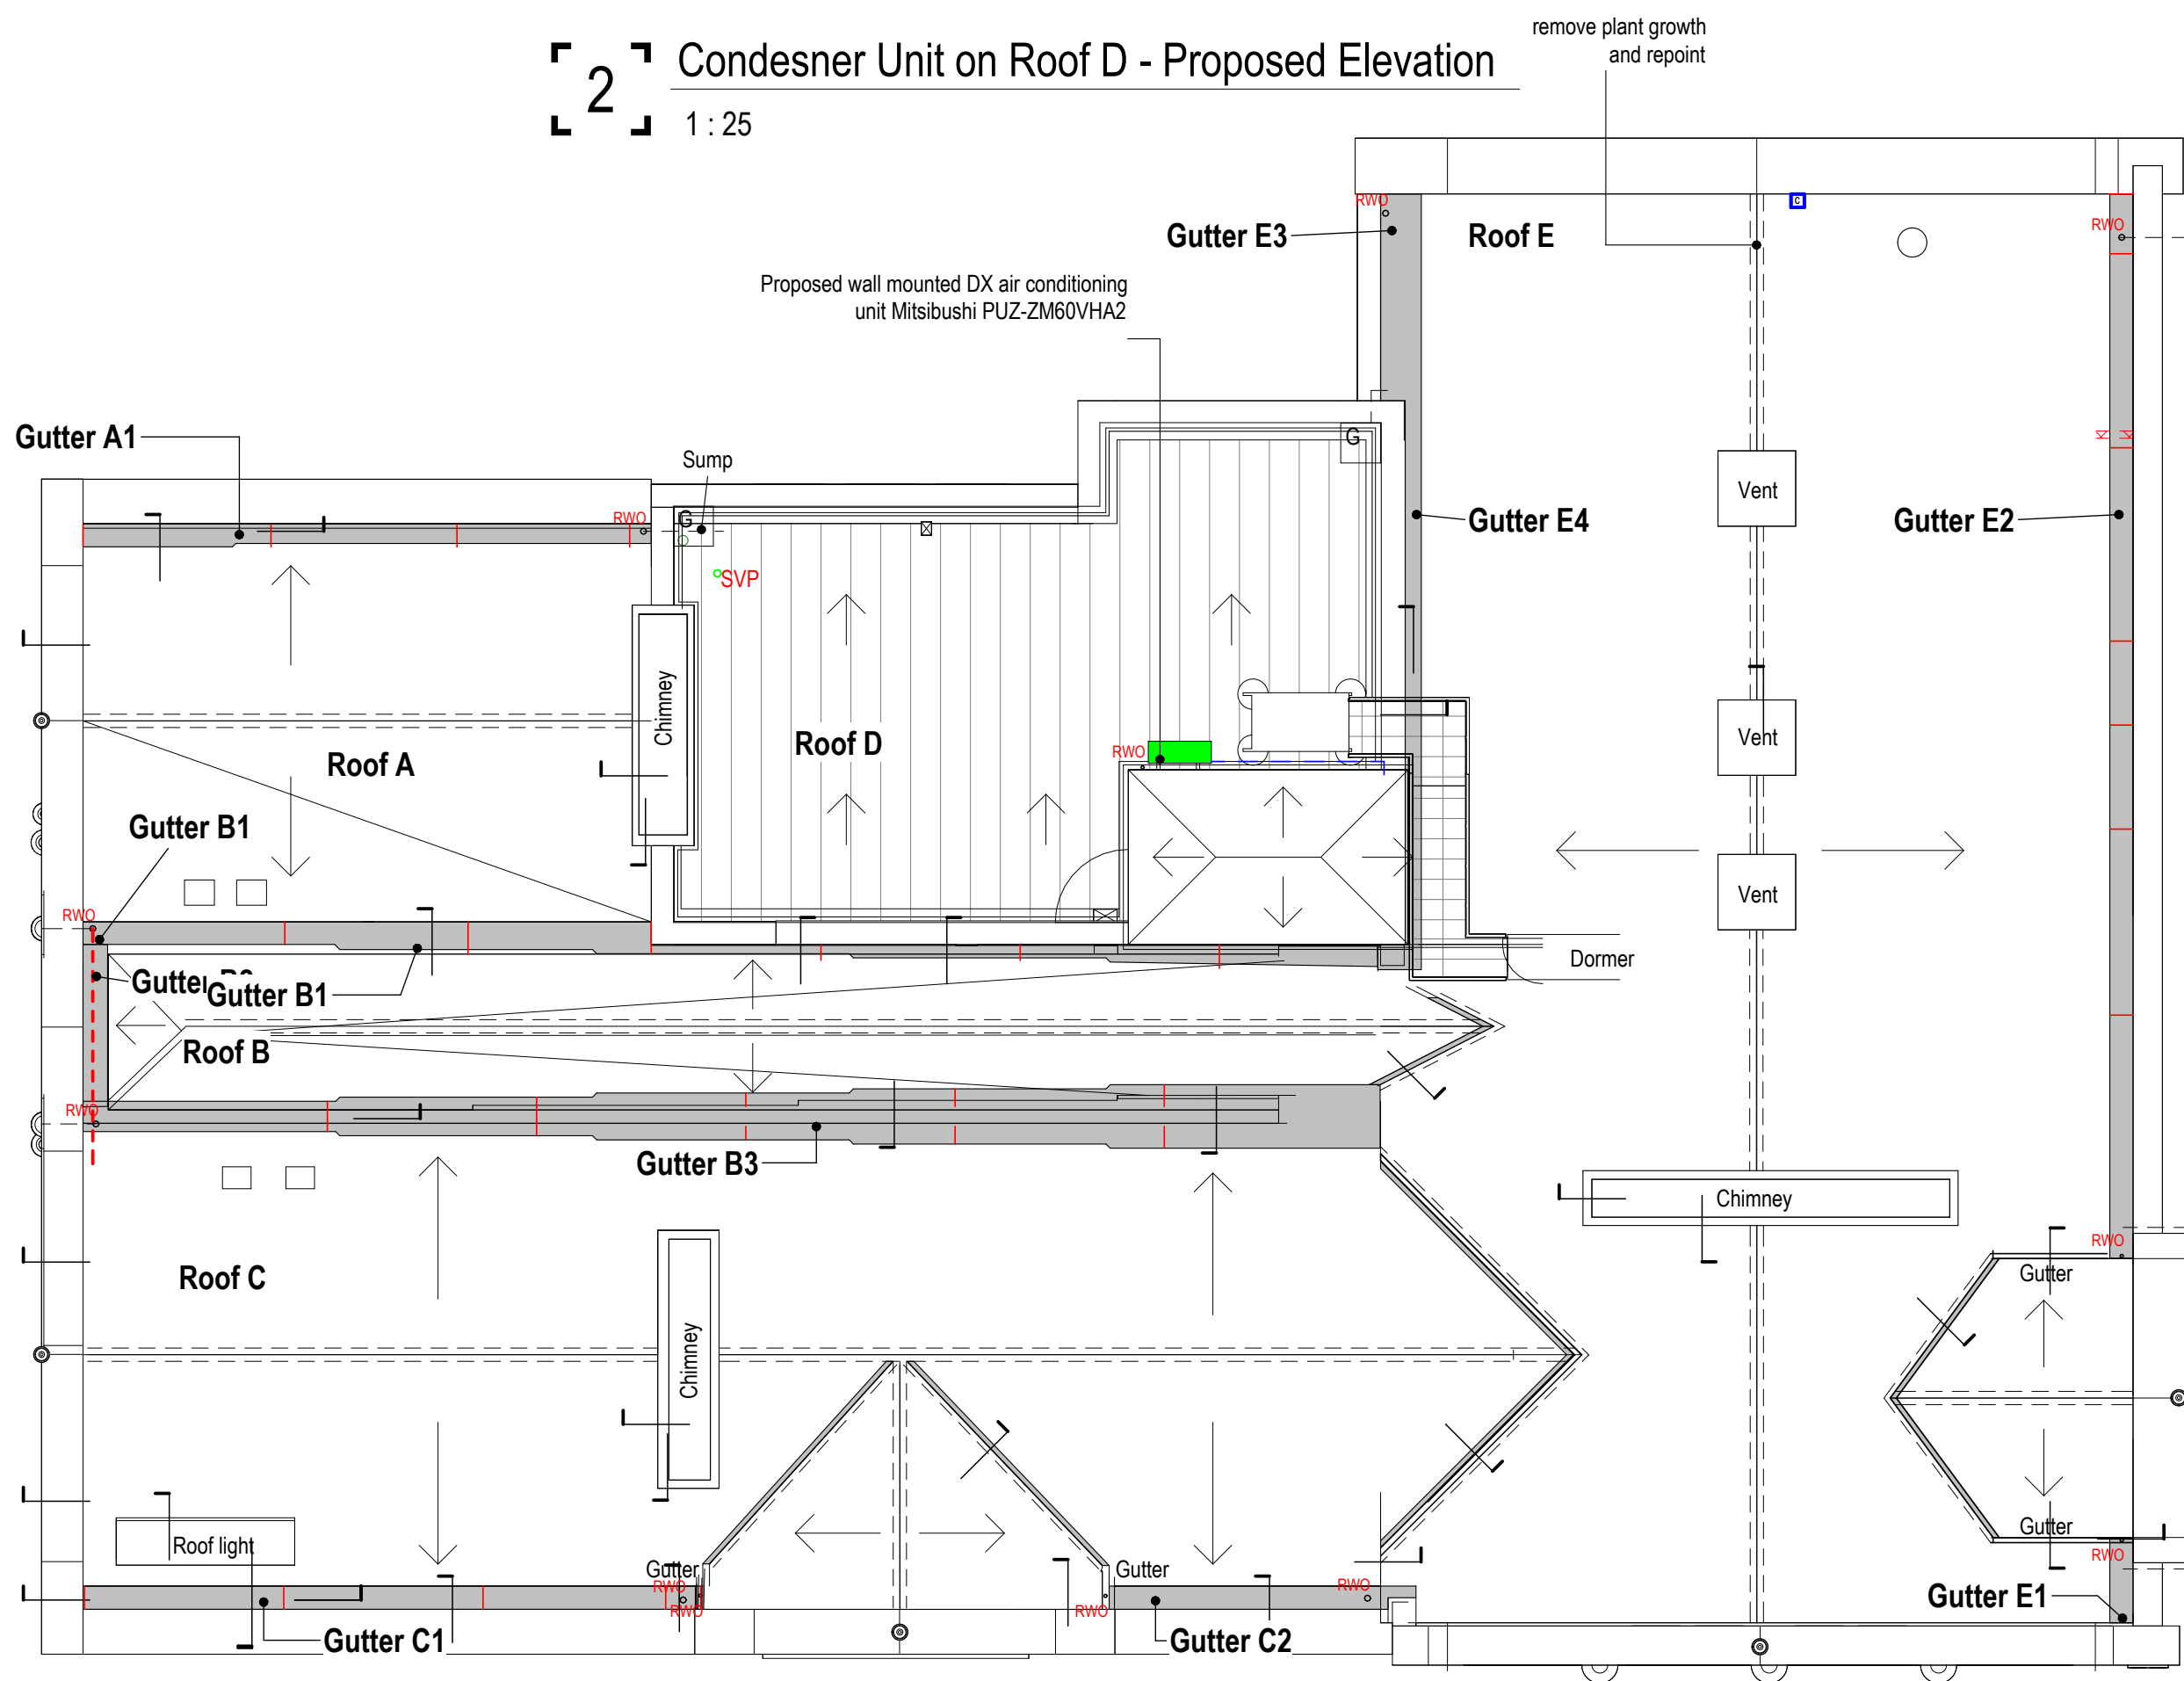

4 Roof Plan - Proposed
1 : 100

Notes:

- This drawing is copyright.
- Do not scale dimensions from this drawing.
- This drawing is to be read in conjunction with all other relevant drawings.
- All discrepancies on this drawing are to be reported to the architect.
- Do not modify any element of this drawing.
- Use drawing only for purpose(s) issued.
- This drawing may contain colour.

Scale Bar

0

1m

3m

5m

Scale: 1:100

North Point

Key Plan

The following external model files are included within this drawing:

RBUM-IBI-XX-XX-M3-A-000000_Shared Levels and Grids	M&F
RBUM-IBI-XX-XX-M3-A-000010_CAD Container	M&H
RBUM-IBI-XX-XX-M3-A-000013_CAD Container	M&I
UOMRB-ABE-ZZ-ZZ-M-Z-00001 - Central	M&N
UOMRB-CAD-ZZ-ZZ-M-Z-00001_A4-C09	M&O

Rev	Date	Revision Notes	Drawn	Review
MANCHESTER 1824 The University of Manchester				
ARCADIS				
Project Rutherford Building				
Drawing Title Proposed Roof Plan & Elevation				
Job Number 141532	Date NOV'23	Security Classification	Drawn By MTW	Reviewed By RM
Scale@A1 As indicated	Purpose LISTED BUILDING CONSENT	Drawing Number 2465-RBUM-ARC-XX-RL-DR-A-2465	Revision	