

PROJECT DESCRIPTION:

SYSTEM SIZE	67.89KW DC STC
MODULE TYPE	(146) JINKO 48HL4M-DB 450-475 465W
INVERTER TYPE	(1) SOLAR EDGE THREE PHASE SE50K - 50KW

INDEX SHEET

A.00	SITE PLAN
A.01	LAYOUT PLAN
A.02	STRING PLAN
E.00	ELECTRICAL SCHEMATIC
S.00	FRAMING LAYOUT
S.01	INVERTER LAYOUT
D.00-D.03	SPECIFICATION SHEET

..\\..1. Sales Docs\\Logo.jpg

C6 SPECTRUM
BUSINESS ESTATE
ANTHONY'S WAY,
ROCHESTER, KENT
ME2 4NP

PRO. DATE 17/05/2024

DESIGN BY DR

CHECKED BY JD

DATE	REV.	DESCRIPTION
03/07/2025	1	500mm Gaps Between Rows
03/01/2025	2	Show Plant Area
03/07/2025	3	Update Roof Plan
11/07/2025	4	750mm gap Highlighted area
22/07/2025	5	More Panels Add
12/09/2025	6	Layout Change
13/10/2025	7	Layout Change
15/10/2025	8	Issued for construction

PROJECT NAME

MCWFC BUILDING

SHEET NAME

SITE PLAN



SHEET SIZE

ANSI B
279 X 432

SHEET NUMBER

A.00

ARRAY02: (40) JINKO 48HL4M-DB 450-475 465W MODULES

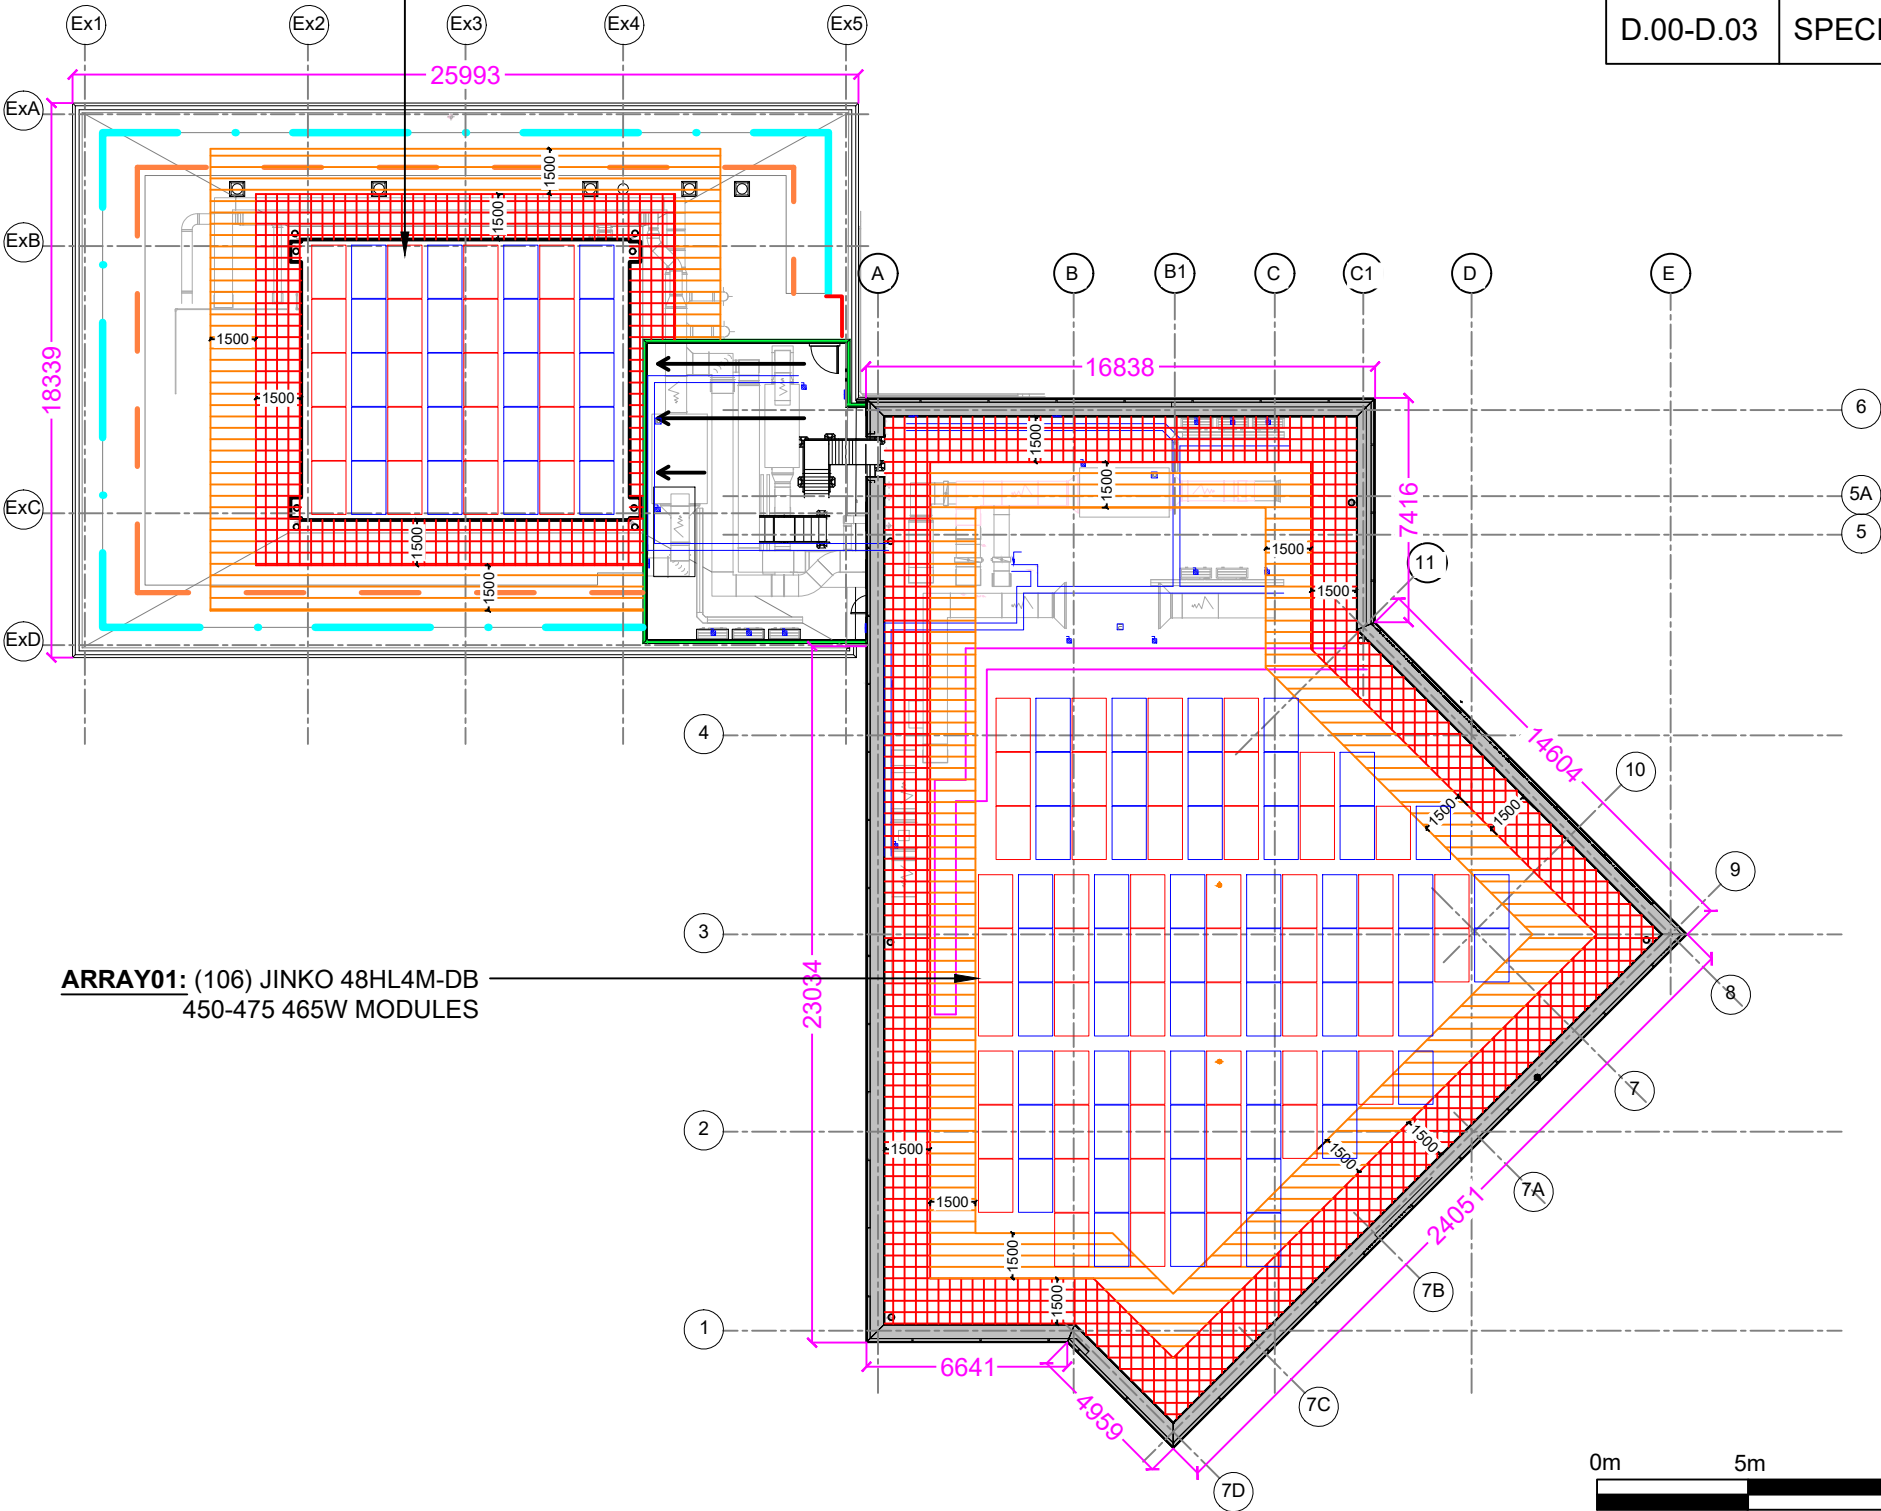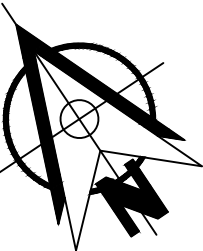

1 SITE PLAN
SCALE: 1:250