
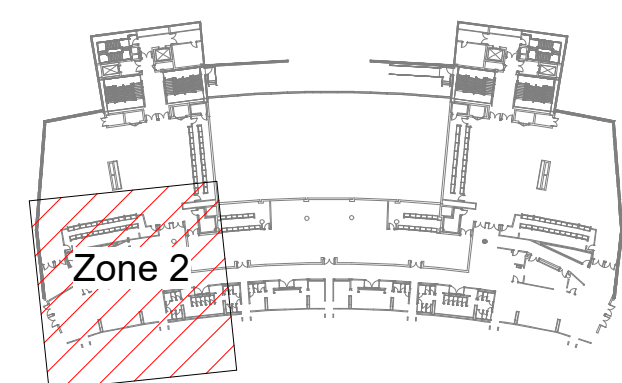


Risk Register	Risk Description	Hazard Colour (Red - Major (Seek Advice) Amber - Review Risk Assessment Green - Caution)	Severity	Risk Rating	Risk Active at Approval	Risk Active at Construction
				(1-5)	(Y/N)	(Y/N)
SCALE	LEVEL OF RISK	SCALE	CONSEQUENCE	SCALE	UNDESIRABLE	
					VERY PROBABLE	
HIGH	ABOVE MODERATE	HIGH	CATASTROPHIC		HIGH	PROBABLE OR FREQUENT
MODERATE	TYPICAL OR NORMAL	MODERATE	MAJOR		MODERATE	POSSIBLE
LOW	BELOW MODERATE	LOW	SEVERE		LOW	UNLIKELY OR REMOTE
VERY LOW	WELL BELOW MODERATE	VERY LOW	MINOR		VERY LOW	REMOTE
THIS RISK BOX IS FOR GUIDANCE ONLY THE CONTENT HAS BEEN PRODUCED BY THE SES TEAM. IT IS IMPERATIVE THAT THE READER OF THIS DOCUMENT REVIEWS ALL RAMSI (RISK ASSESSMENTS / TECHNICAL DOCUMENTATION & METHOD STATEMENTS) BEFORE PROCEEDING.						
001	Working At Height To Install Services	AMBER	3	N	N	N
002	Slip, Trip & Falls	AMBER	2	1	N	N
003	Mechanical Isolations	AMBER	2	N	N	N
004	Electrical Isolations	AMBER	4	N	N	N

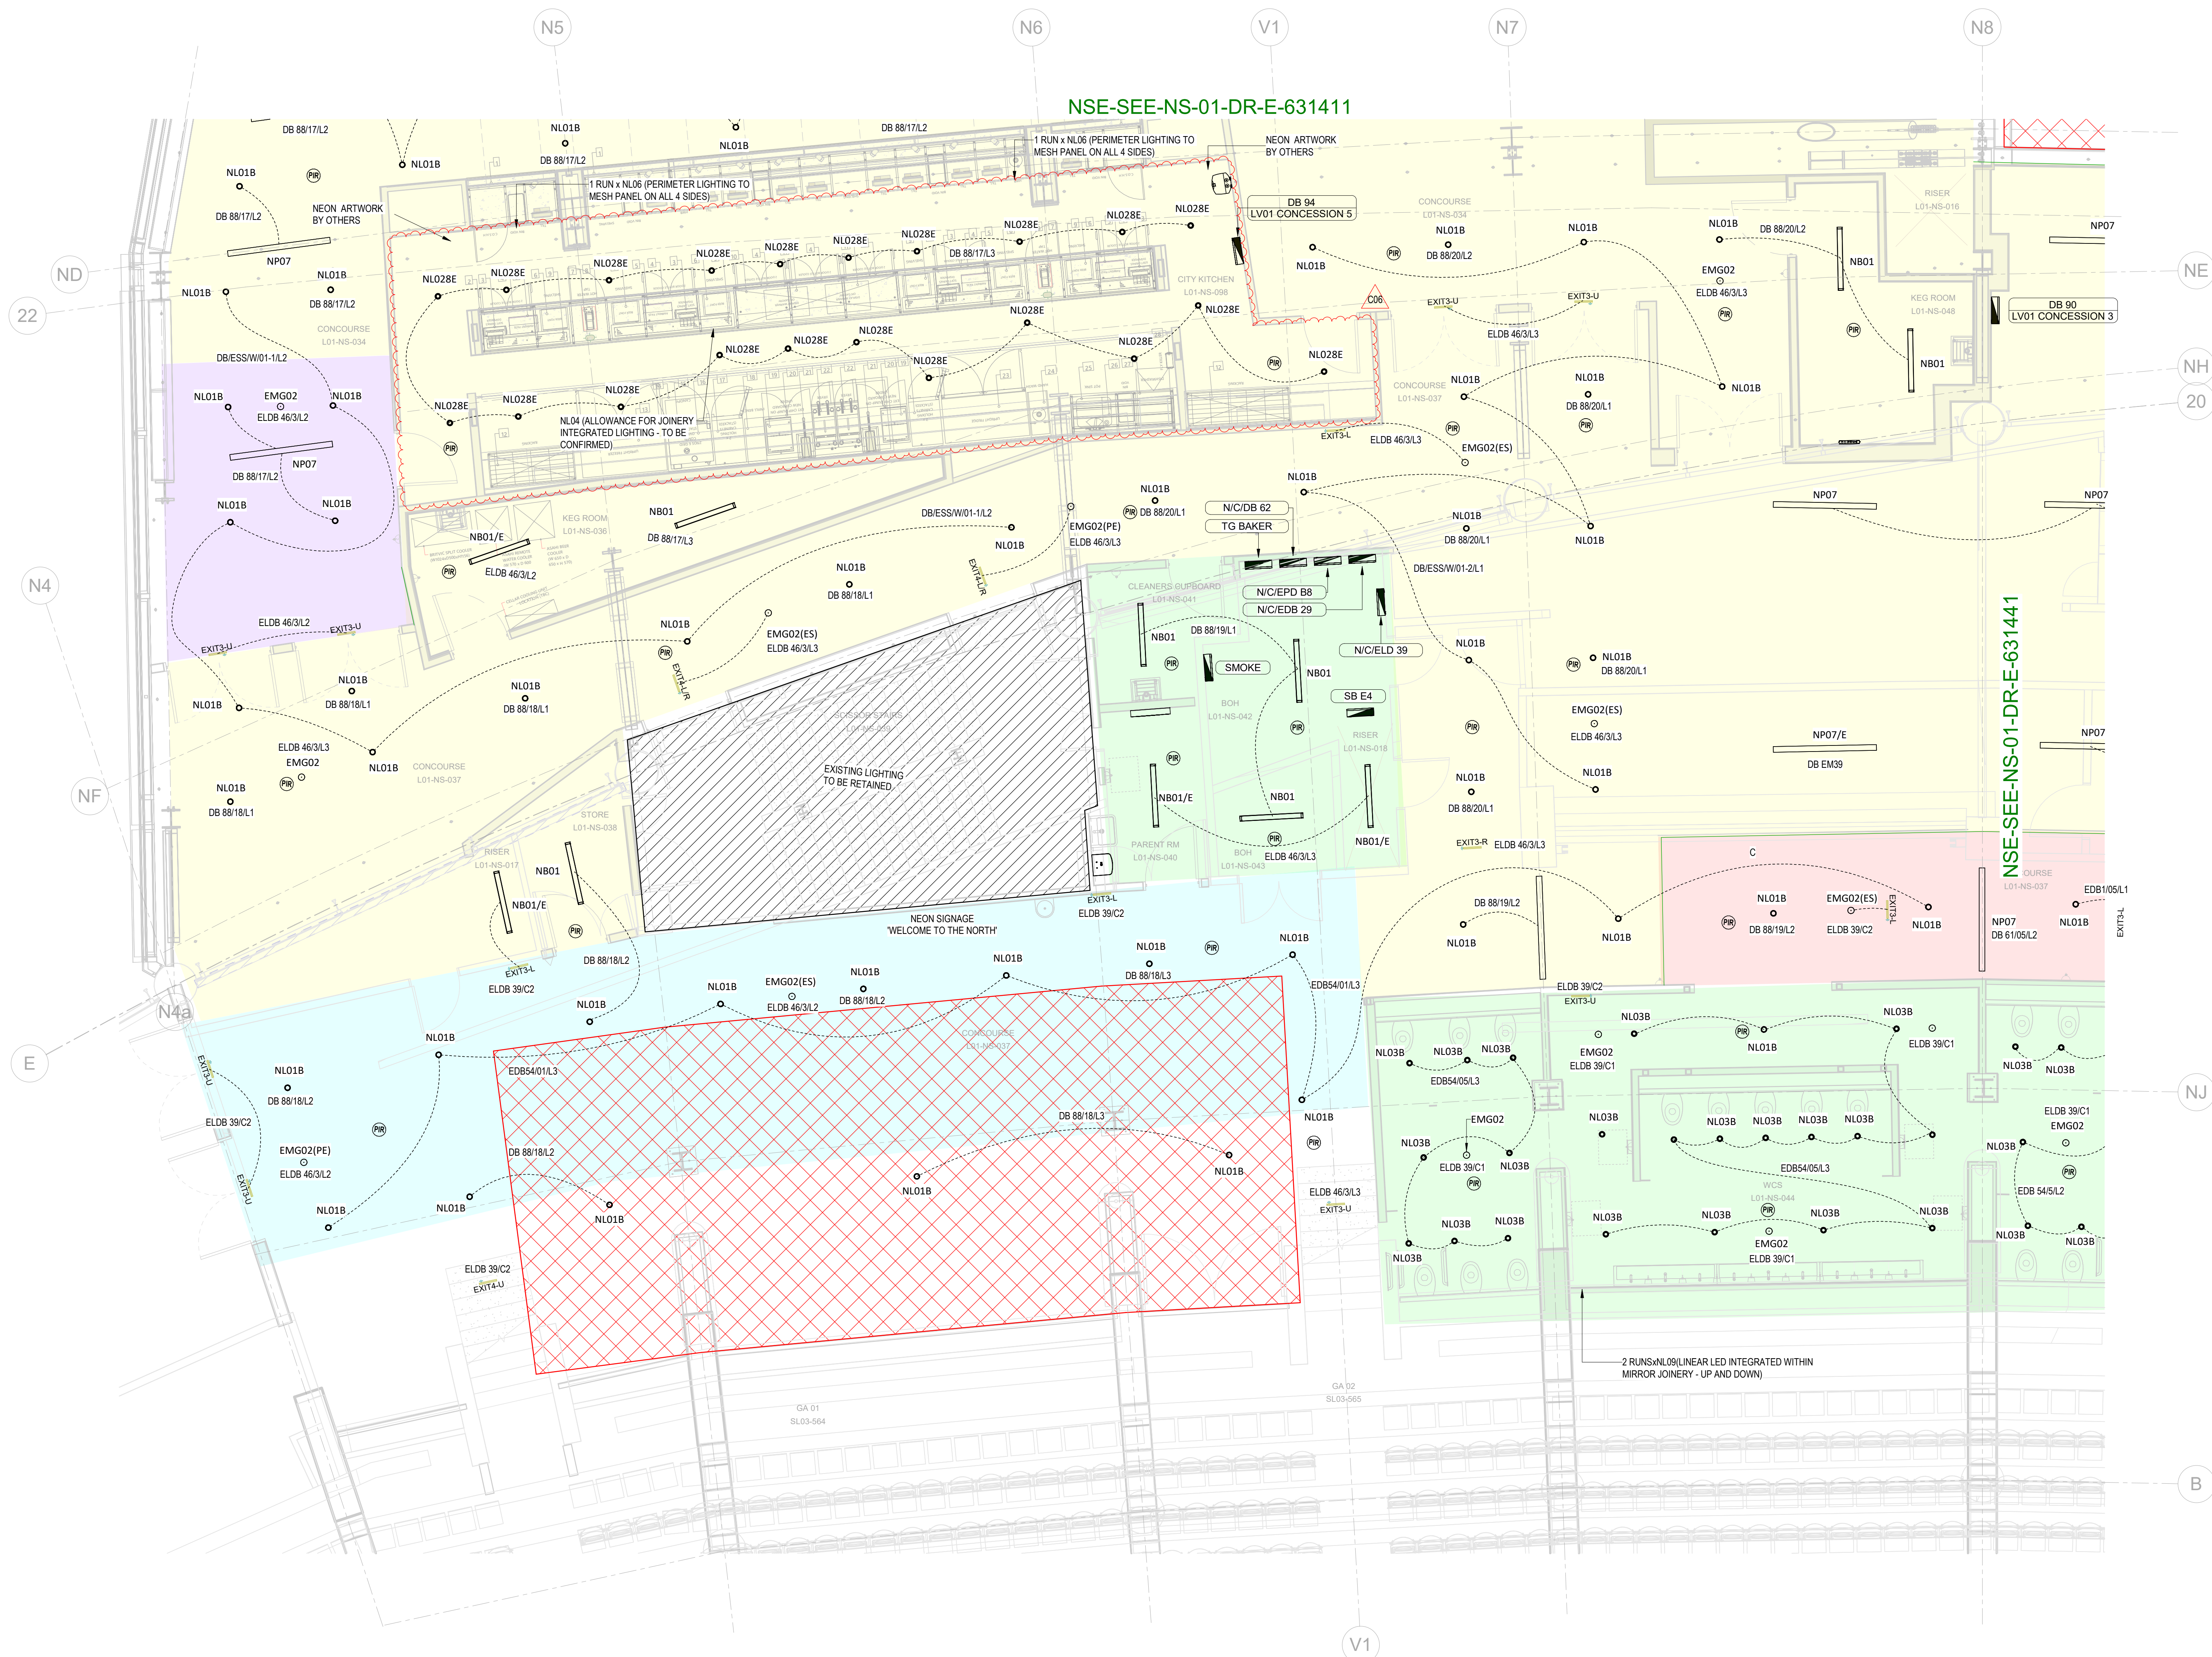


KEY PLAN

 CLIENT DIRECT FIT OUT - WHITEBOX AREAS

LIGHTING NOTES

- THIS DRAWING SHALL BE READ IN CONJUNCTION WITH ALL RELEVANT
STRUCTURAL, ARCHITECTURAL & CONSULTANTS DRAWINGS.
- THIS DRAWING SHALL BE READ IN CONJUNCTION WITH THE SERVICES
SPECIFICATION & ASSOCIATED EQUIPMENT SCHEDULES.
- DO NOT SCALE FROM THIS DRAWING. ALL DIMENSIONS TO BE VERIFIED ON SITE
- THIS DRAWING SHALL ONLY BE USED FOR THE SPECIFIC SERVICES INDICATED
- ALL EQUIPMENT REQUIRED FOR THE SYSTEM SHALL BE PROVIDED AND
INSTALLED IN ACCORDANCE WITH MANUFACTURERS RECOMMENDATIONS
- ENSURE ALL EQUIPMENT AND SYSTEMS ARE INSTALLED TO PROVIDE
ELECTROMAGNETIC COMPATIBILITY WITHIN THE SYSTEMS AND WITH ANY
OTHER SYSTEMS INSTALLED IN THE SAME LOCATION.
- ALL EQUIPMENT LOCATED IN EXTERNAL OR WET AREAS SHALL BE SUITABLY
RATED AND FIT FOR PURPOSE FOR THE ENVIRONMENT, MOUNTING POSITION
AND ORIENTATION
- FINAL COORDINATION AND SETTING OUT OF ALL SERVICES IS TO BE
COMPLETED BY THE NOMINATED MEP CONTRACTOR
- THE CONTRACTOR SHALL PROVIDE LIGHTING TO MEET WITH THE DESIGN AND
SPECIFICATION INCLUDING ALL LAMP SELECTIONS, COLOUR TEMPERATURES
AND CONTRAST RENDERING PROPERTIES.
- THE CONTRACTOR SHALL PROVIDE EMERGENCY LIGHTING THROUGHOUT
INCLUDING ILLUMINATED LEAD EXIT SIGNAGE AS INDICATED ON THE
ARCHITECTURAL DRAWINGS.
- THE COMPLETED INSTALLATION SHALL PROVIDE EMERGENCY EGRESS
LIGHTING THROUGHOUT THE SITE AS MAINTAINED FOR A MINIMUM OF THREE
HOURS DURATION DURING A POWER FAILURE.
- NUMBER AND LOCATION OF EXIT SIGNS TO BE CONFIRMED TO SUIT FINAL
ARCHITECTURAL LAYOUTS AND FIRE ENGINEERS REQUIREMENTS.
- IT IS THE CONTRACTORS RESPONSIBILITY TO ENSURE THAT THE EMERGENCY
LIGHTING INSTALLATION PROVIDES ADEQUATE ILLUMINATION AND UNIFORMITY IN
EACH AREA TO CONFORM TO ALL RELEVANT BRITISH STANDARDS AND
LIGHTING REGULATIONS.
- BUILDING LEVELS, UNIFORMITY ETC. SHALL MEET WITH OHS/ LIGHTING GUIDELINES
- THE CONTRACTOR SHALL ENSURE THAT ALL CONTROL GEAR AND
CONTROLS OF THE SYSTEM ARE SUITABLE FOR LAMP TYPE, VOLTAGE AND
STARTING CHARACTERISTICS. OBTAIN FROM MANUFACTURERS WRITTEN
CONFIRMATION OF COMPATIBILITY.
- ALL LUMINAIRES SHALL BE SUPPLIED WITH PHOTOMETRIC DATA IN
ACCORDANCE WITH EN 13032-1. THE CONTRACTOR SHALL ENSURE THAT
LIGHTING OF SIMILAR TYPE ARE PROVIDED WITH SAME PHOTOMETRIC
PERFORMANCE AS PUBLISHED DATA WITHIN THE TOLERANCES DEFINED BY EN
13032-1.
- ALL LUMINAIRES SHALL BE SUPPLIED IN ACCORDANCE WITH EN 60598
WITH CLASSIFICATION TO EN 60598-1. ALL LUMINAIRES SHALL COMPLY WITH EN
60598-2-1 AND EN 60598-2-2
- ALL LUMINAIRES SHALL BE PROVIDED COMPLETE WITH LAMP/CONTROL GEAR
AS SPECIFIED WITHIN THE LUMINAIRE SCHEDULES.
- WHERE CONTROL GEAR IS REMOTE TO THE LUMINAIRE, LOCAL EQUIPMENT IN
SEPARATE LOCKABLE CABINET OF SHEET STEEL, WITH SAME DEGREE OF
PROTECTION AND FINISH SPECIFIED FOR LUMINAIRE, COMPLY WITH
ANY OTHER RECOMMENDATIONS FOR MAXIMUM CABLE LENGTH
BETWEEN GEAR AND LAMP.
- ALL EMERGENCY LIGHTING LUMINAIRES SHALL COMPLY WITH BS 5266
THE CONTRACTOR SHALL ENSURE THAT ALL LUMINAIRES AS PART OF THE
EMERGENCY LIGHTING INSTALLATION ARE MARKED WITH AN ICEL
CERTIFICATION LABEL.
- GOOD WORKSMANSHIP BY COMPETENT PERSONS ON PERSONS UNDER THEIR
SUPERVISION AND PROPER MATERIALS SHALL BE USED IN THE ERECTION OF
THE ELECTRICAL INSTALLATION. ELECTRICAL EQUIPMENT
SHALL BE INSTALLED IN ACCORDANCE WITH THE INSTRUCTIONS PROVIDED BY
THE MANUFACTURERS OF THE EQUIPMENT.
- LIGHTING CONTROL SHALL BE PROVIDED BY LIGHTING CONTROLS SYSTEMS TO
ENABLE SCENE SETTING, DIMMING AND AUTOMATED CONTROL AS REQUIRED

L01 LIGHTING HEIGHTS

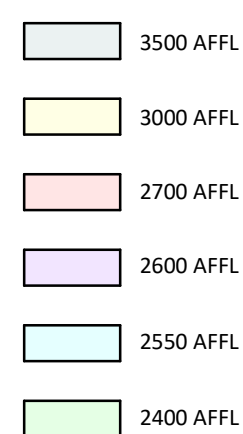

C06	JM	BG	12/09/25	Lighting Updated To Park Lighting Design Rev I
C06	JM	BG	08/08/25	Off Season Works Issued As-Filled
C04	JBD	BG	12/06/25	Issued For Construction
C03	JM	BG	12/05/25	Layout & Essential DB Locations & Circuity Updated
C02	RJS	BD	16/04/25	White Box Area Amended
C01	JBD	BG	23/01/25	Issued For Construction
P04	JM	BG	17/12/24	Issued For Comments
P03	AR	CE	30/08/24	Stage 4i Issue
P02	AR	CE	23/08/24	Stage 4i Issue - Updated Whitebox Areas
P01	AR	CE	12/07/24	Stage 4i Issue
Rev	Dm	Cx'd	Date	Description

Scale Original Size
As indicated A0

Status
A5 - FOR AUTHORISATION AS STAGE
COMPLETE

Client

Project
MCFC

Title

NORTH STAND LIGHTING LAYOUT
LEVEL 01 ZONE 2

Drawing No.	Revision
NSE-SEE-NS-01-DR-E-631421	C06

SES (Engineering Services) Ltd
Think Park
Building Three
Mosley Road
Trafford Park
Manchester
M17 1FQ
(T) 0161 945 5589
(W) www.ses-ltd.co.uk