

Note: This drawing is to be used for 'Roof Plan' purposes only

This drawing is to be read in conjunction with Portakabin Limited drawing numbers:

PTK-A1-00-D-A-1001 - G A Floor Plan
PTK-A1-00-D-A-1401 - Fire Strategy Appraisal
PTK-A1-00-D-A-1903 - Proposed Site Plan
PTK-A1-00-D-A-2001 - G A Elevations

This drawing is to be read in conjunction with all relevant M&E Consultant detail design drawings and specifications


Copyright Portakabin Limited 2025.

Porta and Portakabin are registered trademarks.

This drawing is the property of Portakabin Limited. It must not be copied, reproduced or divulged to anyone without written permission.

Do not scale off this drawing. All discrepancies to be reported to Portakabin Limited.

Rev:	Date:	Description:	By:	Chk:
P01	10/11/25	First Issue	MC	SPM
P02	01/12/25	PV layout added to suit LP Swift Electrical dwg no C2384-LPS-XX-ZZ-DR-E-6901-P01 in email 1st December 2025	MC	SPM
P03	23/12/25	PV layout updated to suit LP Swift Electrical dwg no C2384-LPS-XX-ZZ-DR-E-6901-P02 in email 2nd December 2025	MC	SPM
P04	16/02/26	RWP relocated (between Grids 9/10), PV annotation added	MC	SPM
P05	22/02/26	RWP relocated (between Grids 9/10) following removal of cladding	MC	SPM

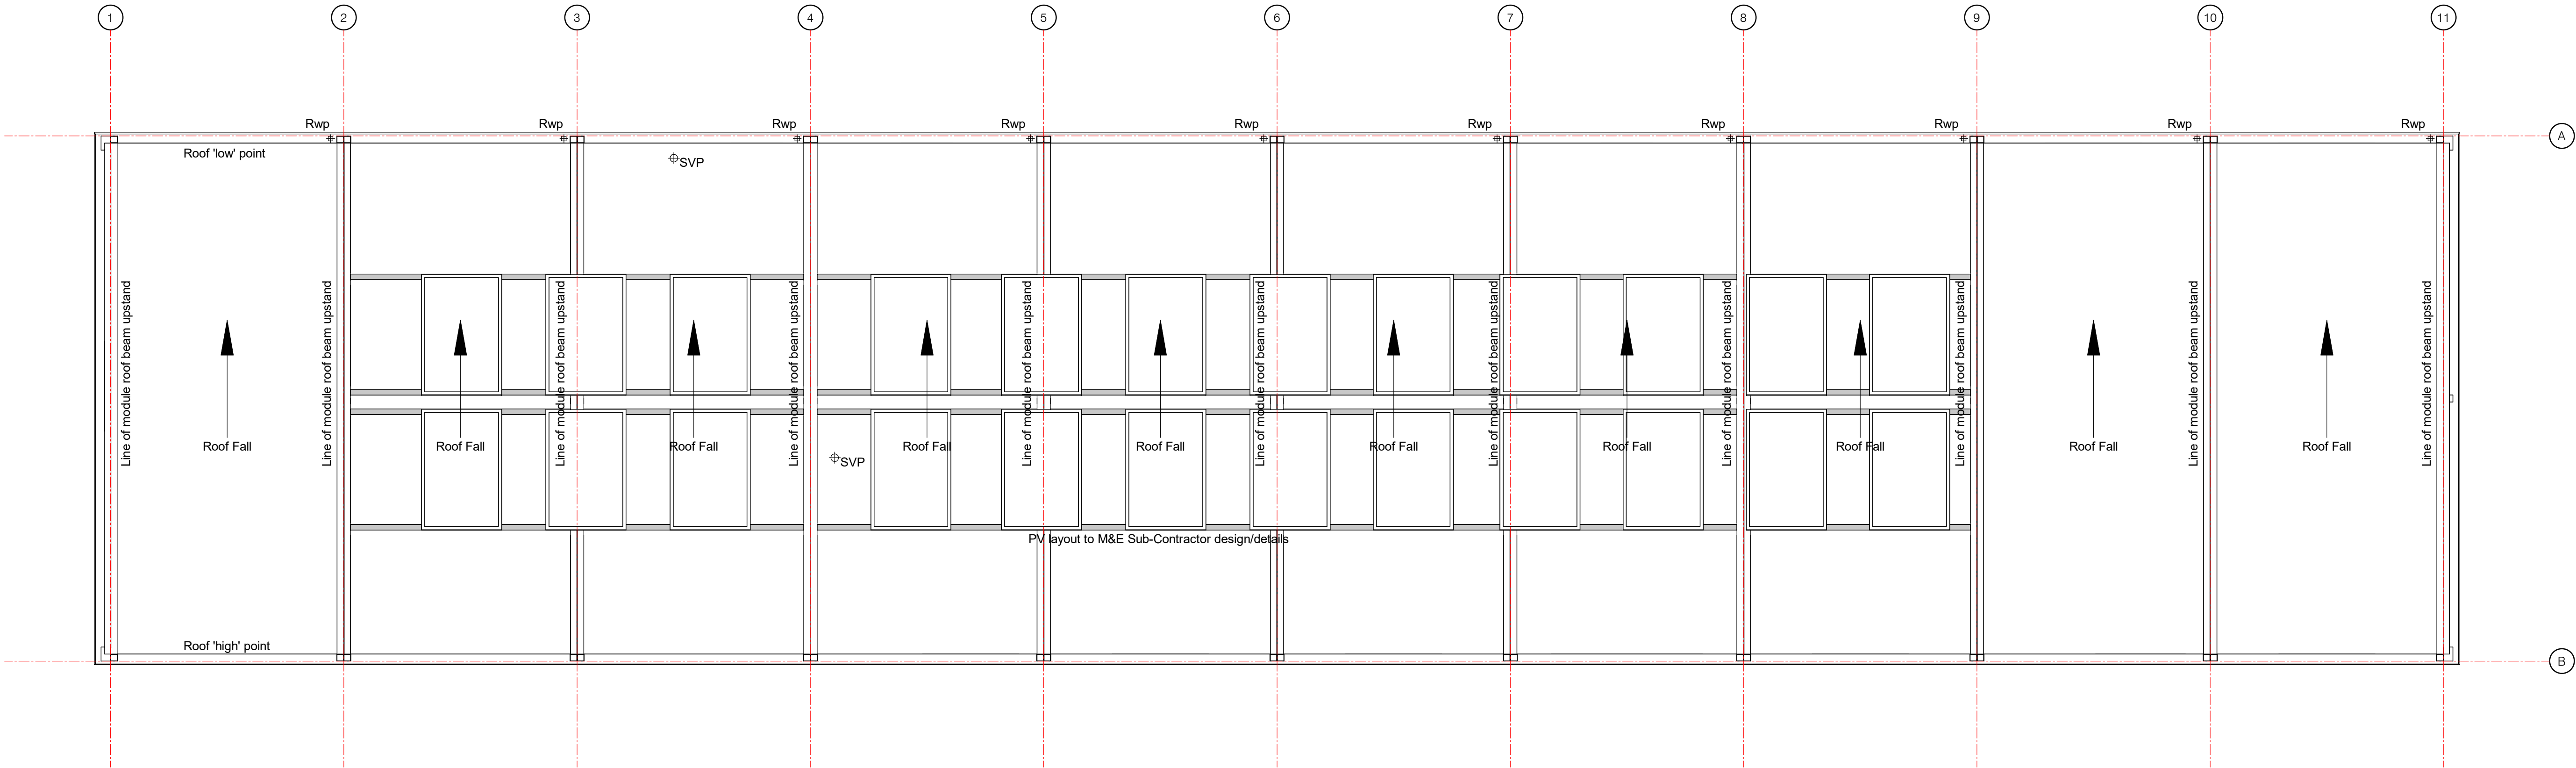

Status: S0
Client: Turner & Townsend
Project: YIF 23 NACRO Wythenshaw
Title: Roof Plan

Scale @ A1: 1 : 50
Date: 10/11/25
Drawn By: MC
Checked By: SPM
Opportunity Number: OPP1374278
Project Number: 17042
Document Number: PTK - A1 - 01 - D - A - 1002
Rev: P05

