

ALL FOH VISIBLE ACCESSORIES TO BE BRASS FINISH
ALL BOH AND NON VISIBLE ACCESSORIES TO BE WHITE FINISH

SYMBOL LEGEND	
	13A SINGLE SWITCHED SOCKET OUTLET
	13A TWIN SWITCHED SOCKET OUTLET
	13A TSSO INCLUDING FLAT SPRUNG COVER
	13A TSSO INCLUDING 2No. 2A USB OUTLETS
	13A UNSWITCHED SINGLE SOCKET OUTLET
	13A TWIN SWITCH UPS SOCKET OUTLET
	13A SWITCHED FUSED SPUR UNIT
	13A UNSWITCHED FUSED SPUR UNIT
	FLEX OUTLET PLATE
	ISOLATION UNIT
	DISTRIBUTION BOARD
	FAN CONTROL UNIT
	DATA OUTLET BOX & CONDUIT BY AGORA
	SPECIAL SOCKET OUTLETS - BS4343 TYPE
	EMERGENCY KNOCK-OFF
	NVR SWITCH
	KEY CARD SWITCH

- INSTALLATION NOTES:
- CABLING WITHIN WALLS TO BE ENCLOSED WITHIN CONDUIT.
 - CONTAINMENT TO RUN WITHIN DEPTH OF LATTICE BEAMS AND WITHIN ROOF VOIDS WHERE AVAILABLE.
 - ALL CONTAINMENT TO BE COORDINATED WITH OTHER INSTALLATIONS AND STRUCTURES.
 - CONTAINMENT SHALL BE STACKED WHERE REQUIRED.
 - ALLOW CONTAINMENT TRUNKING FOR BACK OF THE HOUSE FEATURE LIGHTING. REFER TO ALLISON PIKE DRAWINGS.

SLOT REFERENCES (CONTAINMENT):

SLOT 01 - CEILING CONTAINMENT SIZE 150mm x 100mm
SLOT 02 - CEILING CONTAINMENT SIZE 900mm x 100mm
SLOT 03 - CEILING CONTAINMENT SIZE 200mm x 100mm
SLOT 04 - CEILING CONTAINMENT SIZE 300mm x 100mm

LIGHTING, SMALL POWER CONTAINMENT - REFER TO WIDTH ON DRAWINGS, IN CEILING VOID / FIXED TO BUILDING FABRIC AT 1200 CENTRES.

STRUCTURED CABLING/EPOS CABLE BASKET 150mm WIDE, IN CEILING VOID FIXED TO BUILDING FABRIC AT 1200 CENTRES.

CABLE TRAY - REFER TO WIDTH ON DRAWINGS, USED EXTERNALLY ON ROOF AND INTERNALLY TO ROUTE CABLE AND REFRIGERANT PIPEWORK, MAINS CABLE - RHS/BOTTOM, STRUCTURED CABLE - LHS/TOP, REFRIGERANT PIPEWORK - MIDDLE.

SUBMAINS BASKET - 300mm WIDE, 300W FOR MAIN CABLE BETWEEN ISOLATOR AND MAIN DB

THIS DRAWING TO BE READ IN CONJUNCTION WITH:


THE MECHANICAL AND ELECTRICAL SERVICES SPECIFICATIONS INCLUDING MITCHELLS AND BUTLERS KITCHEN STANDARD VENTILATION POLICY.

ALL ALLISON PIKE DRAWINGS.

ALL STRUCTURAL ENGINEERS DRAWINGS.

THE INSTALLATION TO COMPLY WITH RELEVANT BRITISH STANDARDS & BUILDING REGULATIONS.

ALL CABLING SHALL BE RUN IN CONTAINMENT CONCEALED WITHIN THE BUILDING FABRIC AND CONDUIT PROTECTED WHERE NECESSARY.

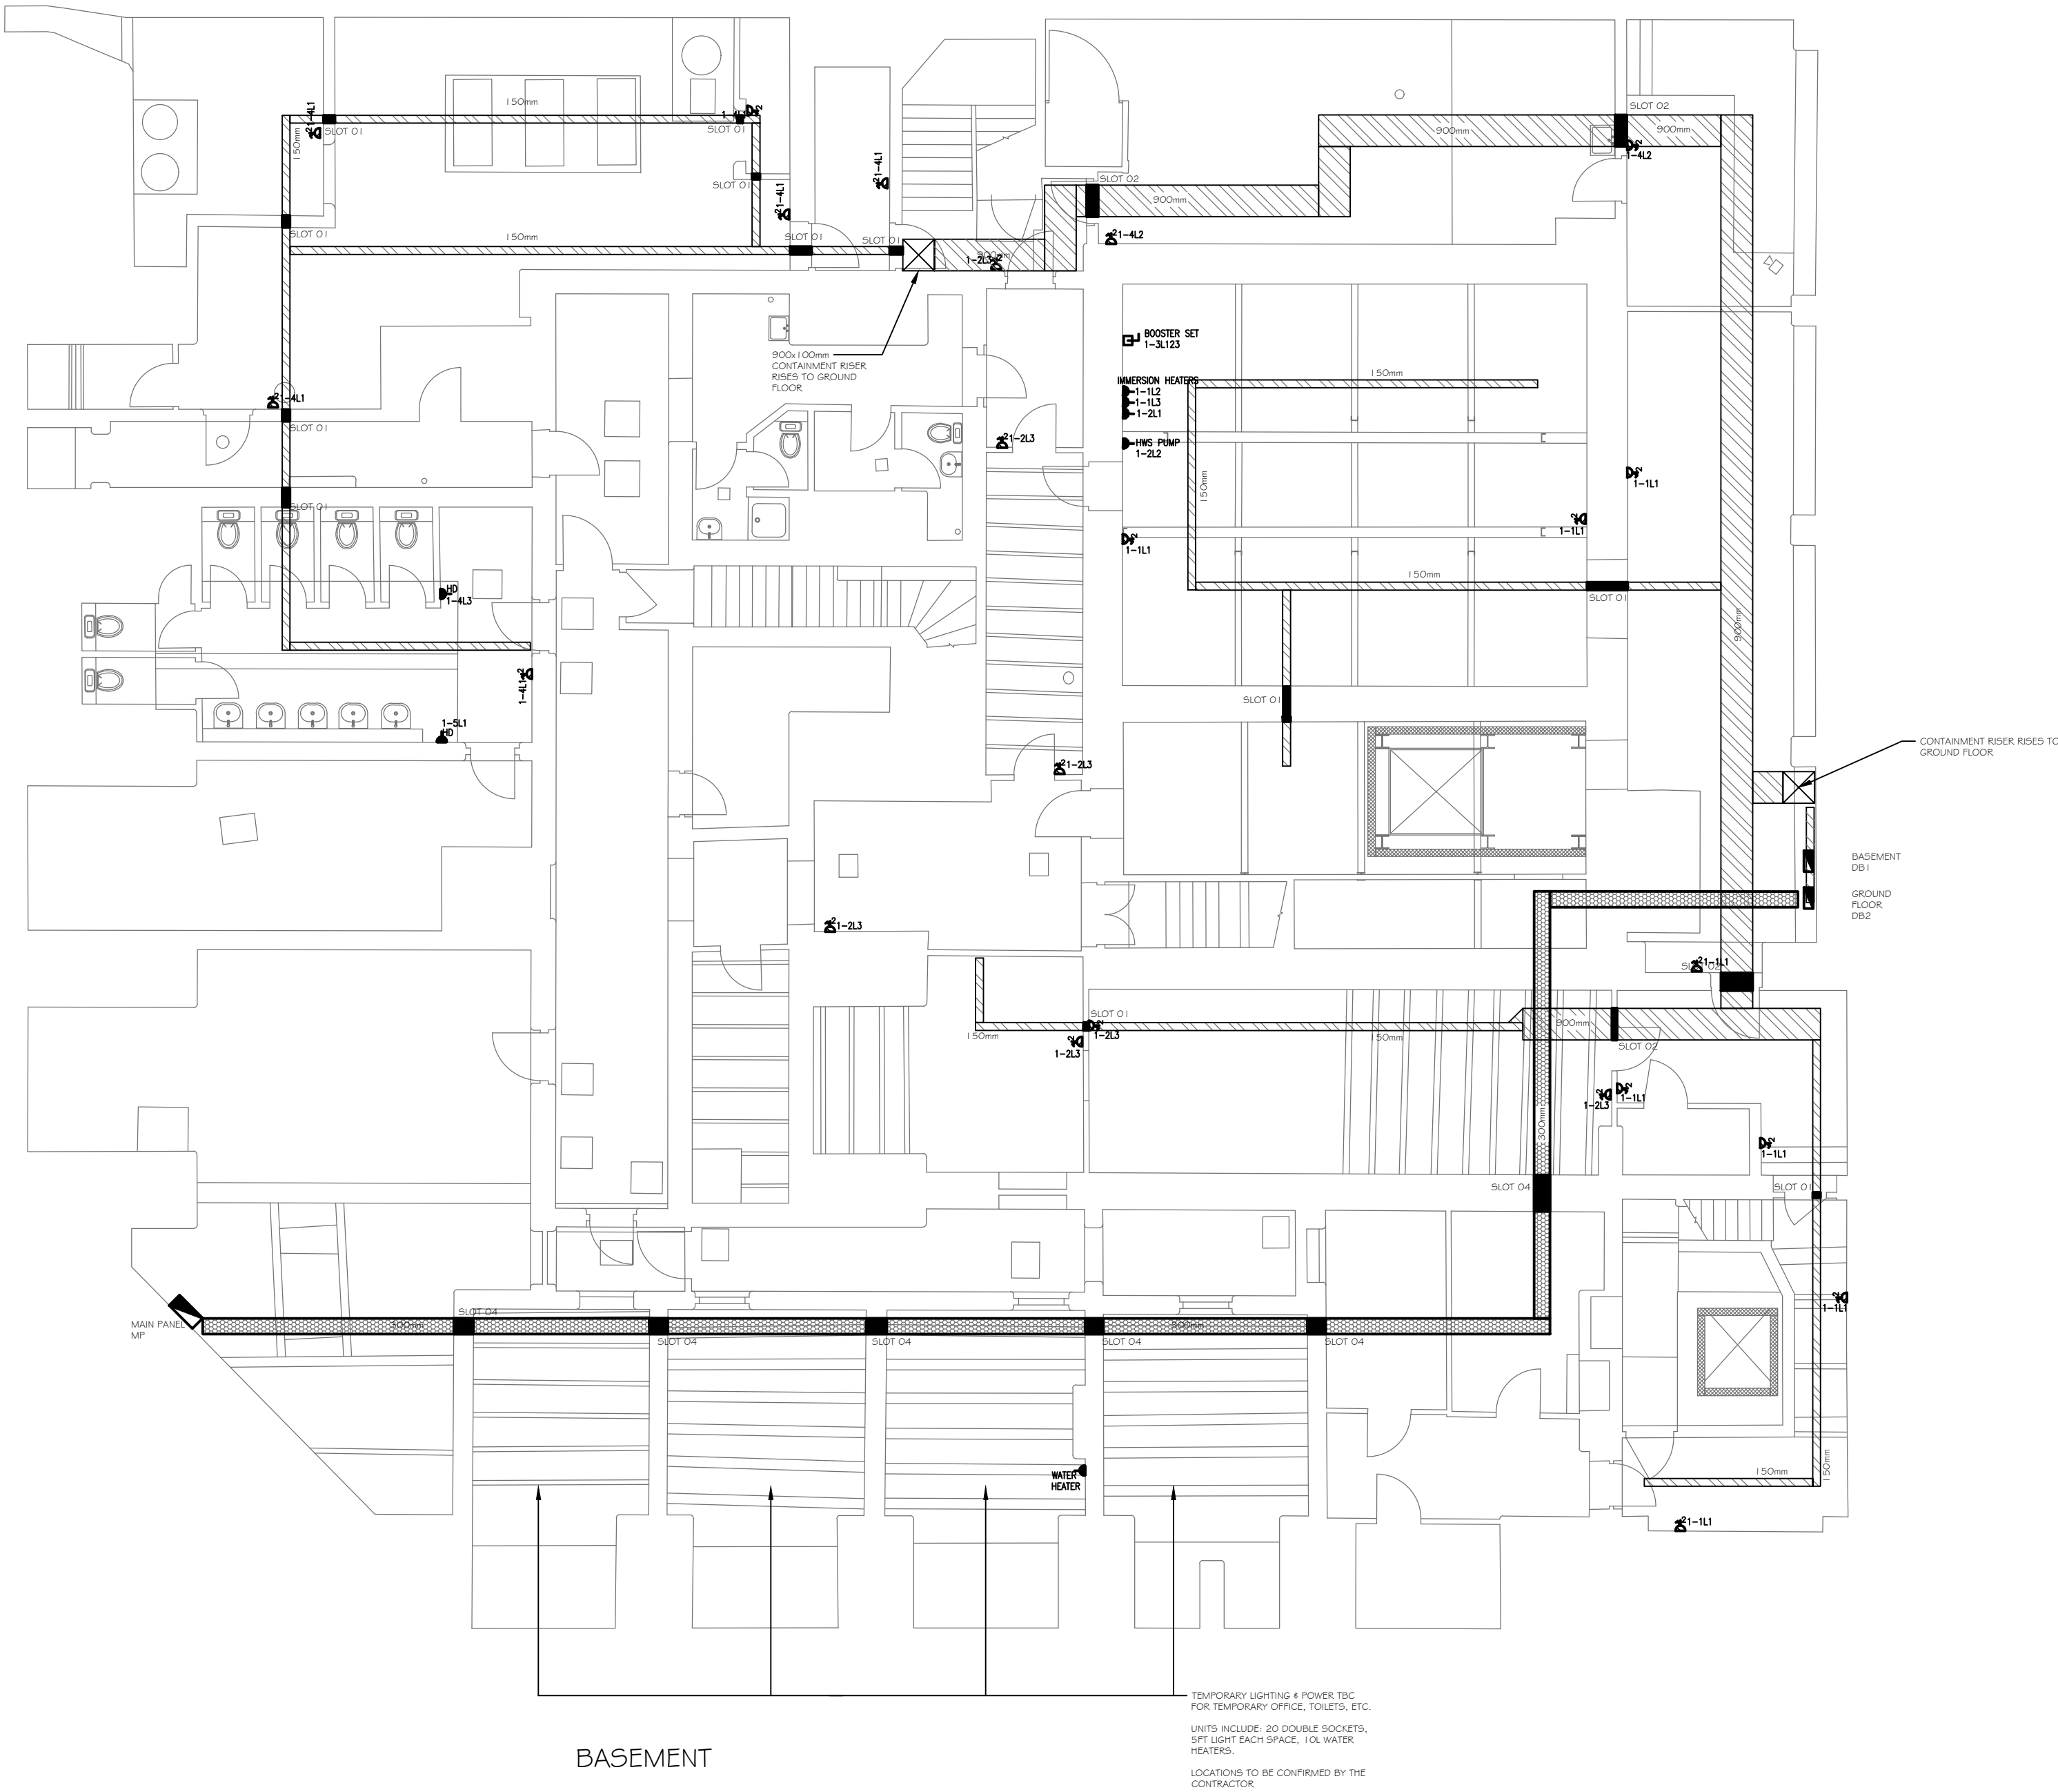

- THIS DRAWING MUST NOT BE SCALED AND ALL DIMENSIONS ARE TO BE CHECKED ON SITE BEFORE WORK IS COMMENCED.
- FOR SETTING OUT DETAILS PLEASE SEE ARCHITECTS DRAWINGS.
- ANY DISCREPANCIES ARE TO BE REPORTED IMMEDIATELY TO THE CONSULTANTS.
- ALL INFORMATION SHOWN ON THE DRAWING IS SUBJECT TO OBTAINING THE NECESSARY STATUTORY CONSENTS.

REV	DATE	DESCRIPTION	DRW	ENG
P01	08.08.2025	FIRST ISSUE	DP	PD
P02	19.08.2025	BACK OF HOUSE POWER AND CONTAINMENT ADDED	DP	PD
P03	03.11.2025	REVISED ISSUE	DP	PD
P04	28.11.2025	REVISED ISSUE	DP/LC	PD
P05	22.12.2025	REVISED ISSUE	DP/LC	PD

Client	Mitchells & Butlers Plc
BMT Project No. / Project Title	B3322



Project Address
INNKEEPERS COLLECTION
1-3 YORK STREET (BROWNS)
MANCHESTER

Drawing Title
M&E SERVICES INSTALLATION
POWER & CONTAINMENT
BASEMENT LEVEL

Job No.	Originator	Zone	Level	Type	Role
B3322	BMT	ZZ	ZZ	DR	E

System Classification	Drawing No.	Suitability	Revision
Ss_70_30_45_45-2101	D2	P05	

Drawn	Engineer	Date	Scale	Size
DP	PD	05/08/2025	1:100	A1



9208 MELTON ROAD
THURMASTON
LEICESTER
LE4 8GR
TEL: (016)244 0331
E-MAIL: <firstname.surname@bmt-td.co.uk>

This Drawing is Copyright And May Not Be Reproduced in Any Manner Without the Prior Written Consent Of Building Management Technology Ltd