


- LEGEND:**
- 13A SWITCHED FUSED SPUR
 - SINGLE DATA OUTLET
 - DISTRIBUTION BOARD
 - WEC ROADSIDE CABINET (RC RANGE):
THE CABINET SHALL HAVE A SMALL DISTRIBUTION BOARD,
POE SWITCH FOR CCTV POWER, DOOR CONTROLLER FOR
GATE AND PEDESTRIAN GATE ACCESS CONTROL.
 - 100mm LV DUCT
 - 100mm ELV DUCT
 - 150mm LV DUCT
 - 150mm ELV DUCT
 - EXISTING LV DUCT
 - EXISTING ELV DUCT
 - EXISTING ELV DUCT
 - EXISTING ELV DUCT

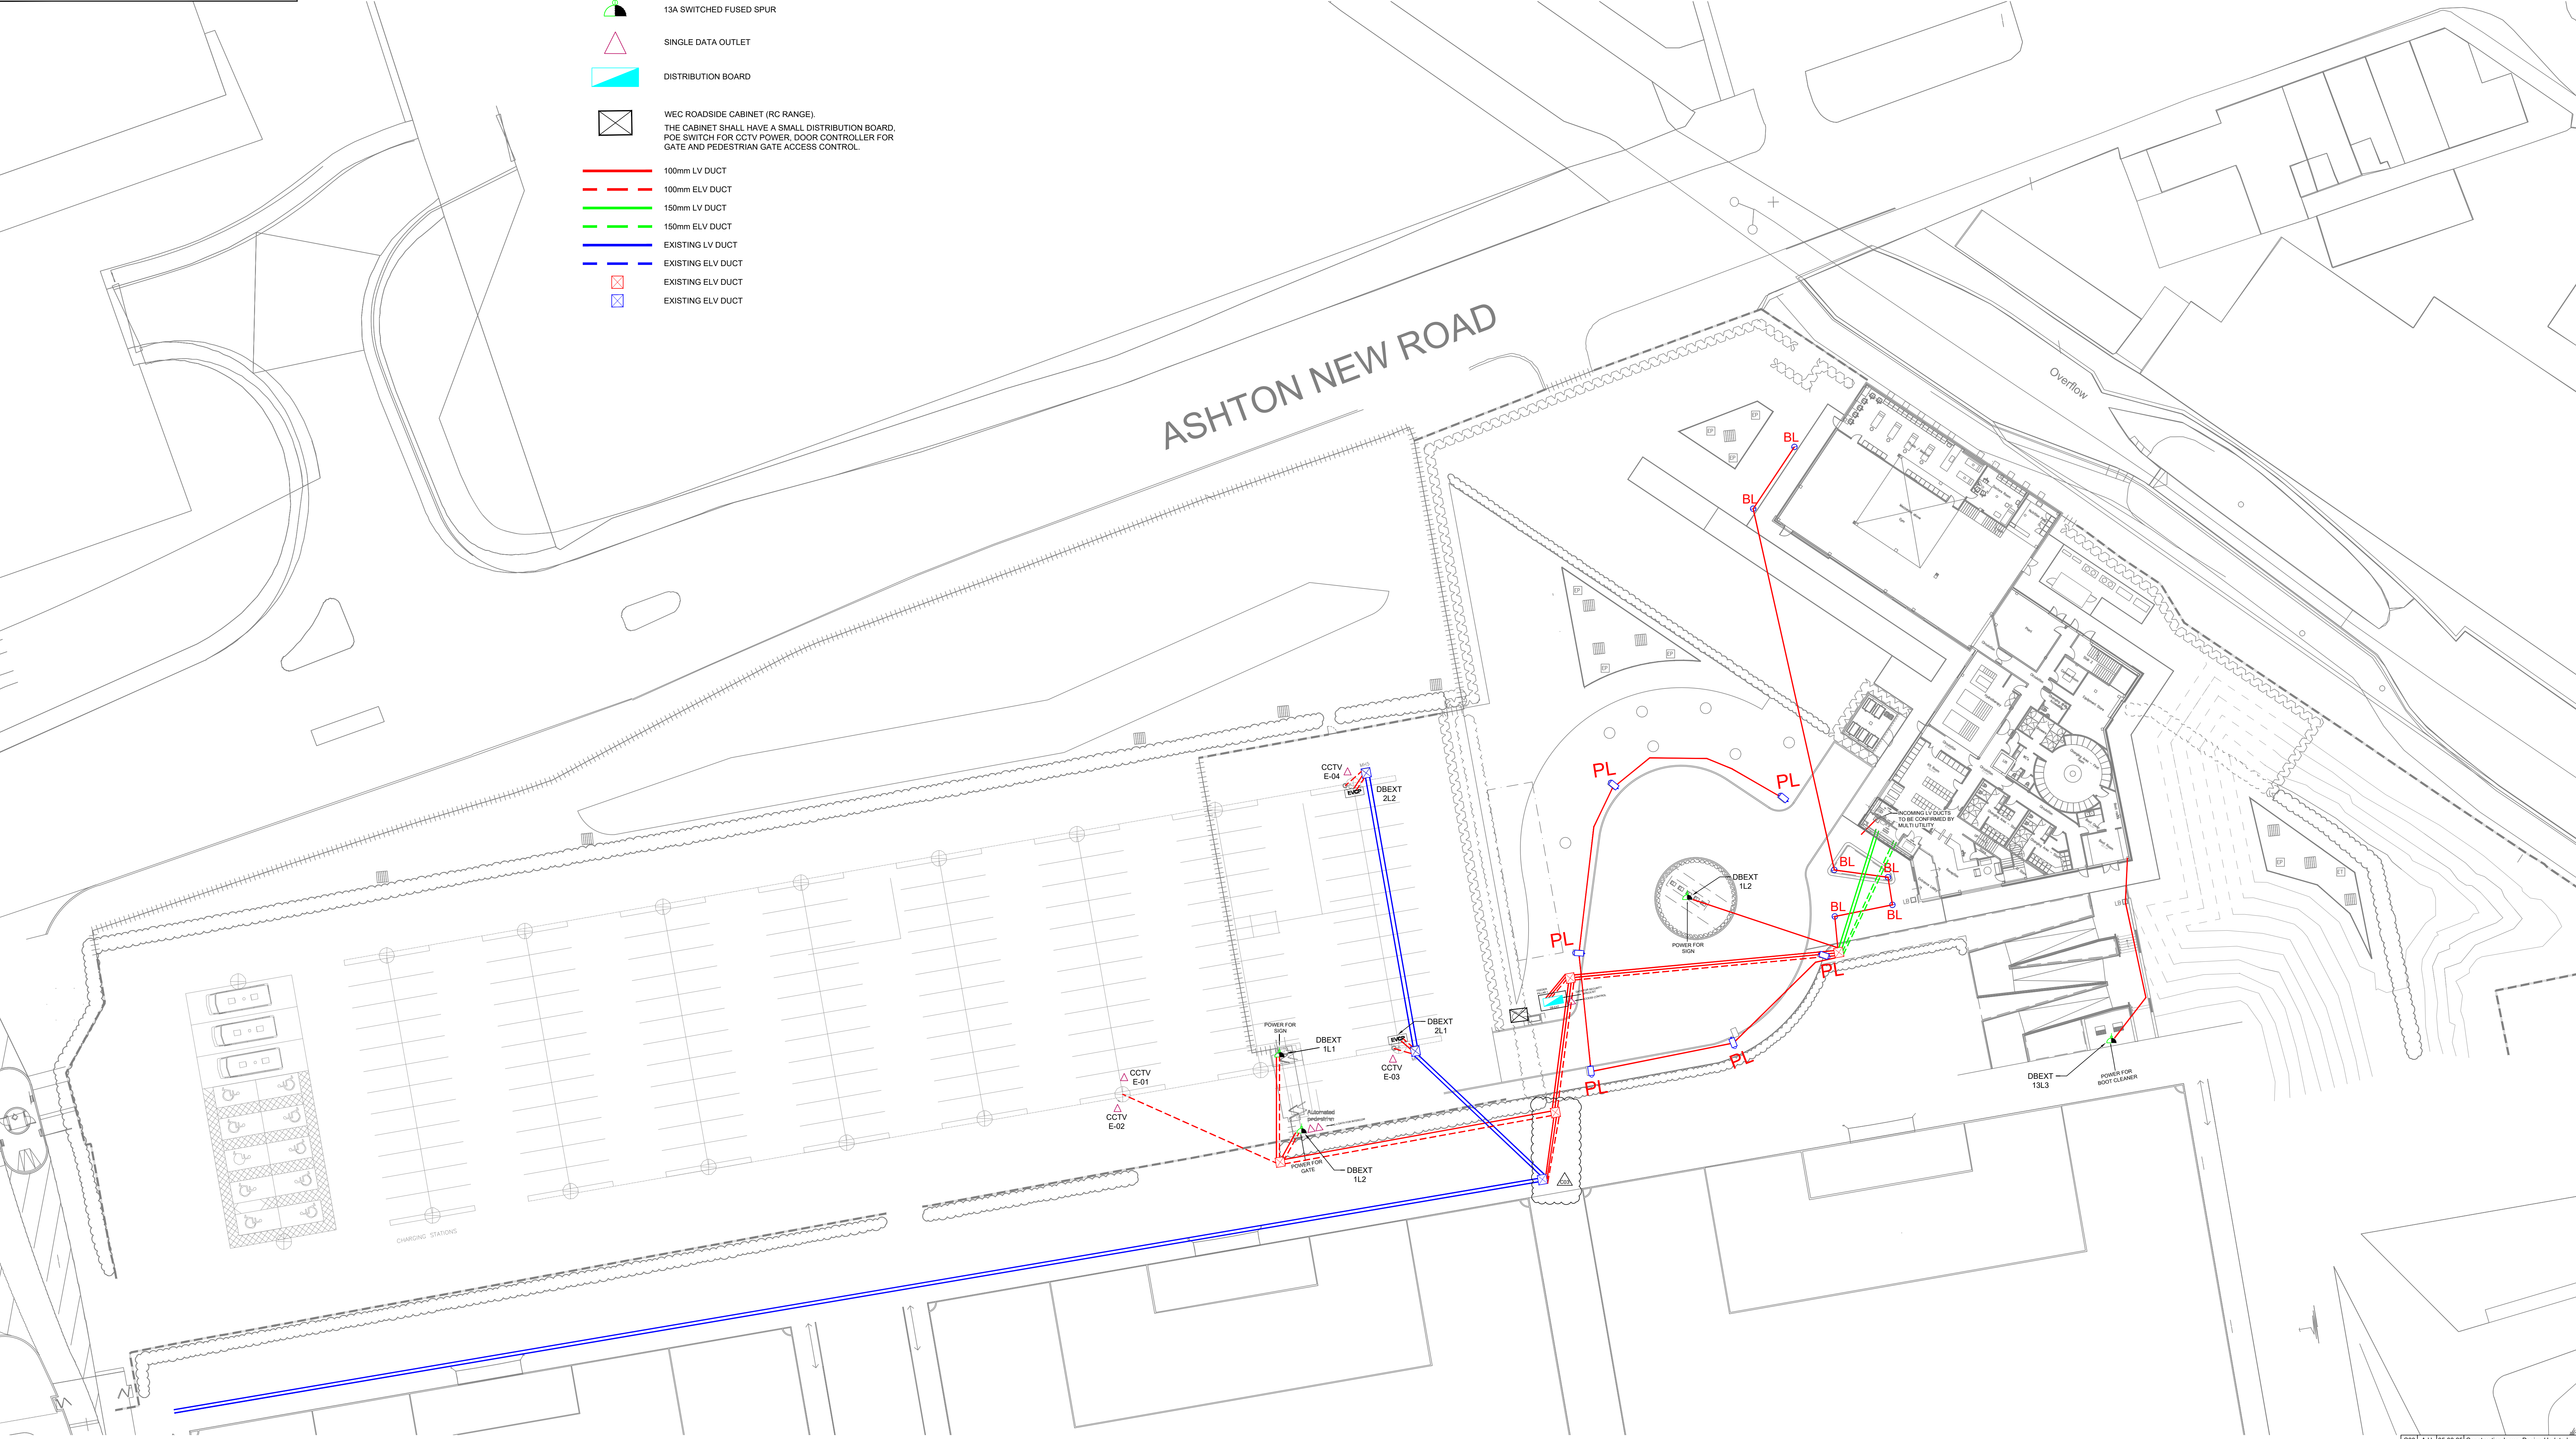

C03	A.H	05.08.20	Construction Issue, Design Updated, Additional Data Added
C02	A.H	23.07.20	Construction Issue, Design Updated, 22-03-2019 Arch Layout Rev J
C01	A.H	01.07.20	Construction Issue
P03	A.H	13.06.20	Power Updated
P02	A.H	04.06.20	Power Updated
P01	A.H	15.05.20	Preliminary Issue

PEL

123 Radcliffe Road, Bury, BL9 9LD T 0161 787 3476
www.performanceelectrical.co.uk

Client: John Turner Construction

Project: MCFC Womens Academy

Drawing Title: External Power Layout

Date: May 2025	Scale: 1:250 @ A0
Rev: C03	Drawing Number: C00311-E017