


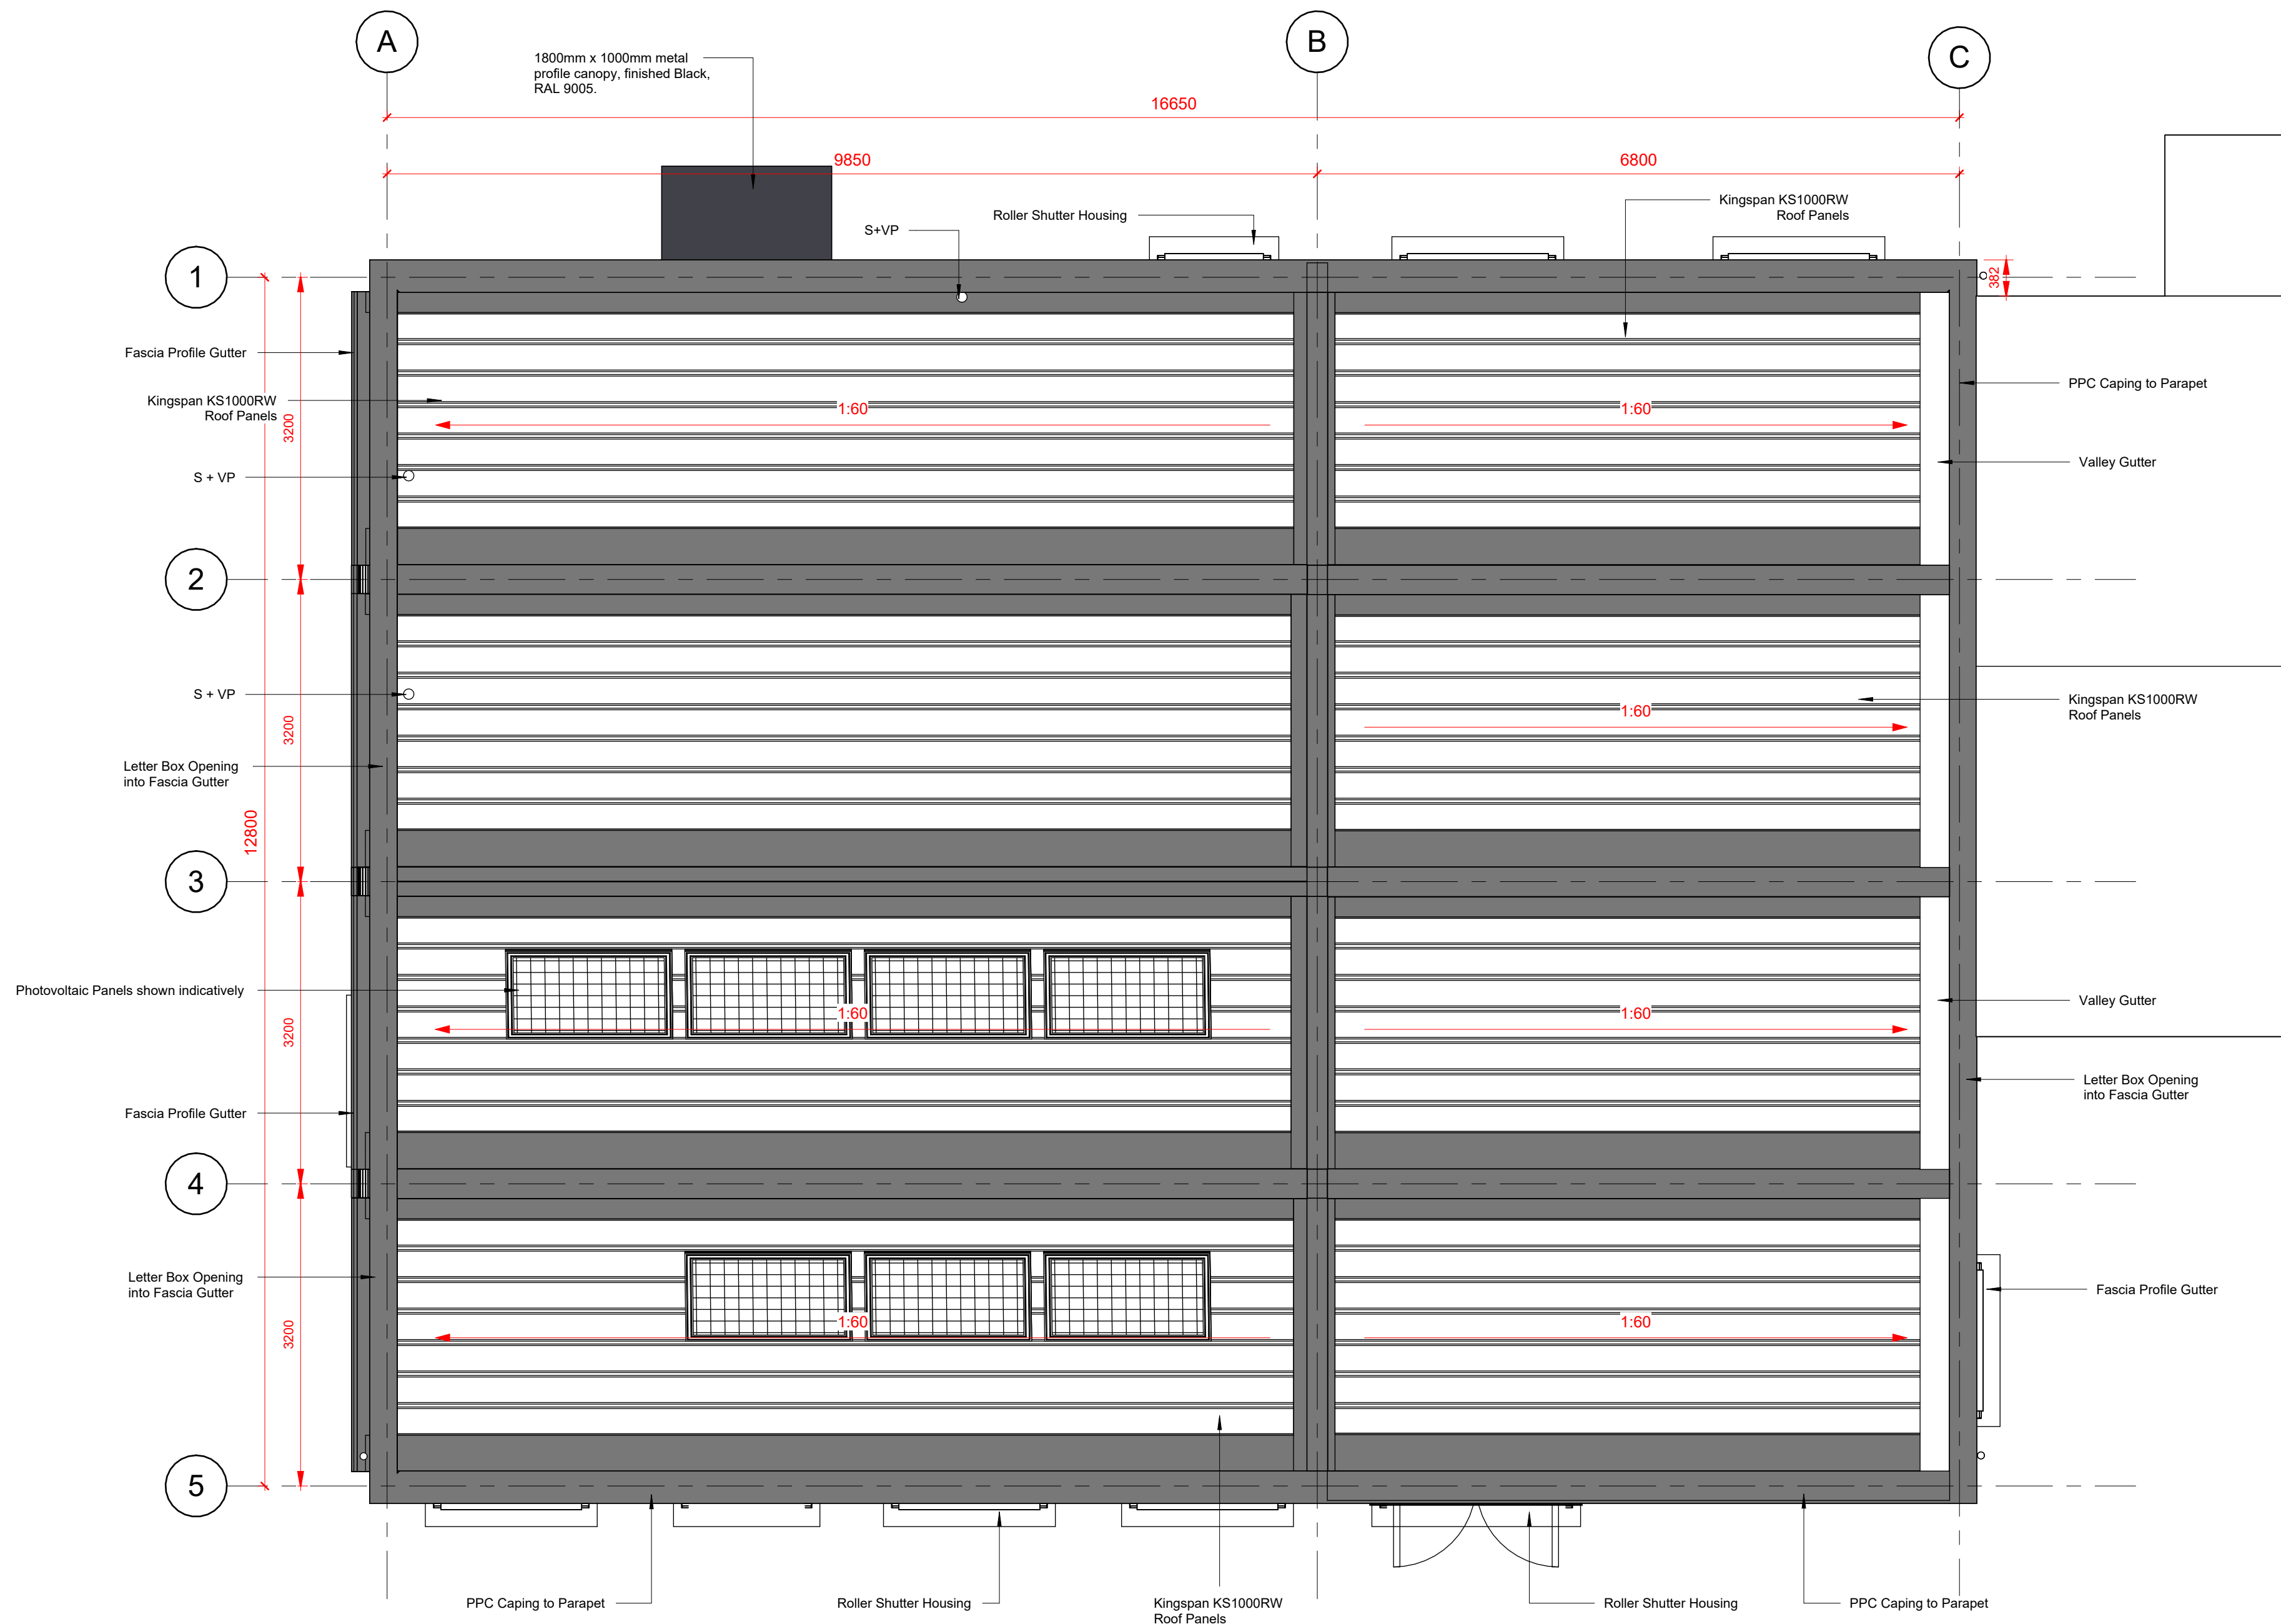

1 GA Roof Plan
1 : 50

Man Safe System

Details of man safe system to be confirmed once requirements for PV System have been confirmed by M+E Engineer

UNLESS STATED OTHERWISE, THE DESIGNS SHOWN ARE SUBJECT TO DETAIL SITE SURVEY AND INVESTIGATIONS AND/OR APPROVAL OF THE RELEVANT VARIOUS LOCAL AUTHORITY OFFICERS, STATUTORY UNDERTAKERS, FIRE OFFICERS AND ENGINEERS. THEY ARE PROJECT AND SITE SPECIFIC.

THIS DRAWING SHOULD NOT BE SCALED FROM.

ALL DIMENSIONS SHOULD BE CHECKED ON SITE.

ANY DRAWING ERRORS OR DISCREPANCIES SHOULD BE REPORTED TO VAUGHAN ARCHITECTURE LTD

THIS DRAWING IS THE COPYRIGHT OF VAUGHAN ARCHITECTURE LTD

DRAWING STATUS

DRAWN BY: JW
SCALE: 1 : 50 @A1
DATE: 20/06/2025

P01	First issue for client comments	12.09.2025	JW	JS
P02	Amended following JS comments	24.09.2025	JW	JS
P03	Amended following PML comments	07.11.2025	JW	JS
P04	External wall build up, details and canopy amended, photovoltaic panels shown	12.01.2026	JW	JS

Manchester N-Gage

PREMIER
MODULAR

Leicester Office:

Vaughan Architecture Ltd
Rutland House
23-25 Friar Lane
Leicester
LE1 5GG
0116 326 8905



Latest Projects

CLIENT Youth Investment Fund
PROJECT TITLE Manchester N-Gage

DRAWING TITLE GA Roof Plan

PROJECT NO. VAD.25.21
DRAWING NO. 40694-PML-XX-DR-A-000005
REVISION P04
STATUS S3

VAUGHAN
ARCHITECTURE

Vaughan Architecture Ltd
No 2
Infirmary Street
Leeds, West Yorkshire
LS1 2JP
0113 493 1055

www.vaughanarchitecture.co.uk