

C-PROBE

Unit 2 Wharton Street
 Sherdley Road Industrial Estate
 St Helens
 Merseyside
 WA9 5AA
 United Kingdom
 T: +44 (0) 1744 611555


www.c-probe.com

Title

**Rylands Building
 Manchester
 North Elevation**

Legend / Notes

— Electrical containment for ICCP cables

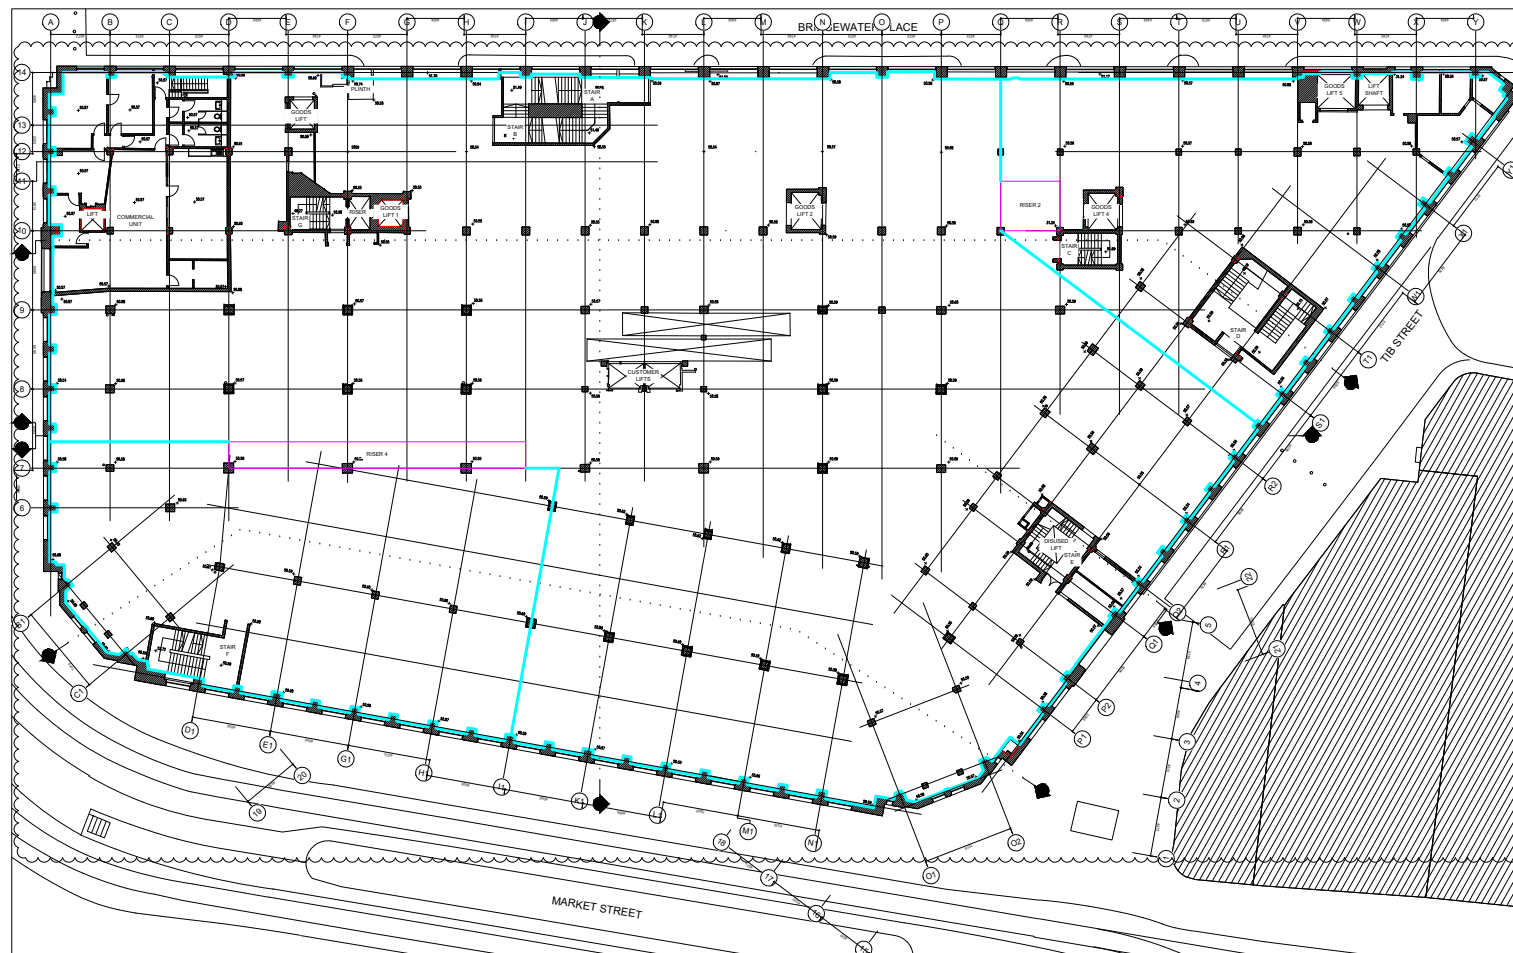

Issue Description Drawn Date

Revisions

Drawn	Authorised	Sheet No.	Sheet size
YC	SD	1 of 6	A3

Date	Scale	Project No.
30/01/2025	1:150	10596

Drawing No.	Revision
10596-CP-006	

C-PROBE SYSTEMS LIMITED
 Specialists in Corrosion Management
www.c-probe.com

