



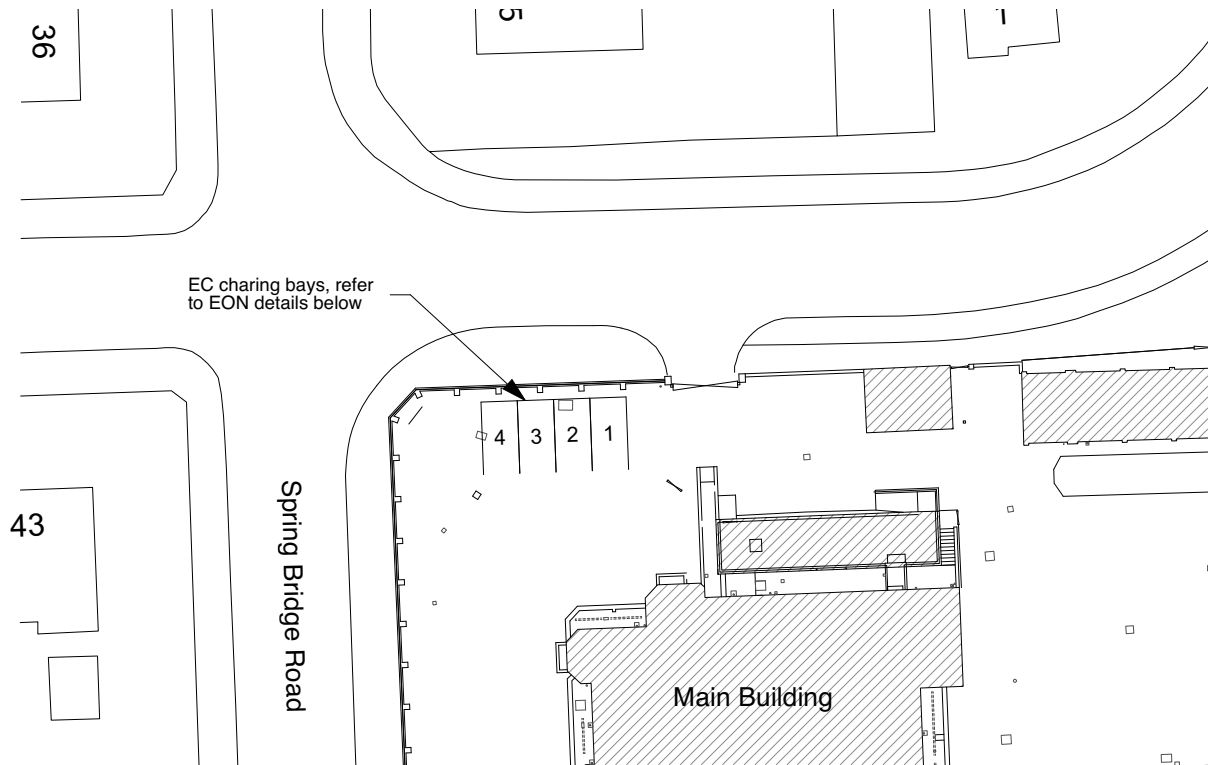

1 Site Plan
Scale: 1:500

Sports Hall


Proposed EV location

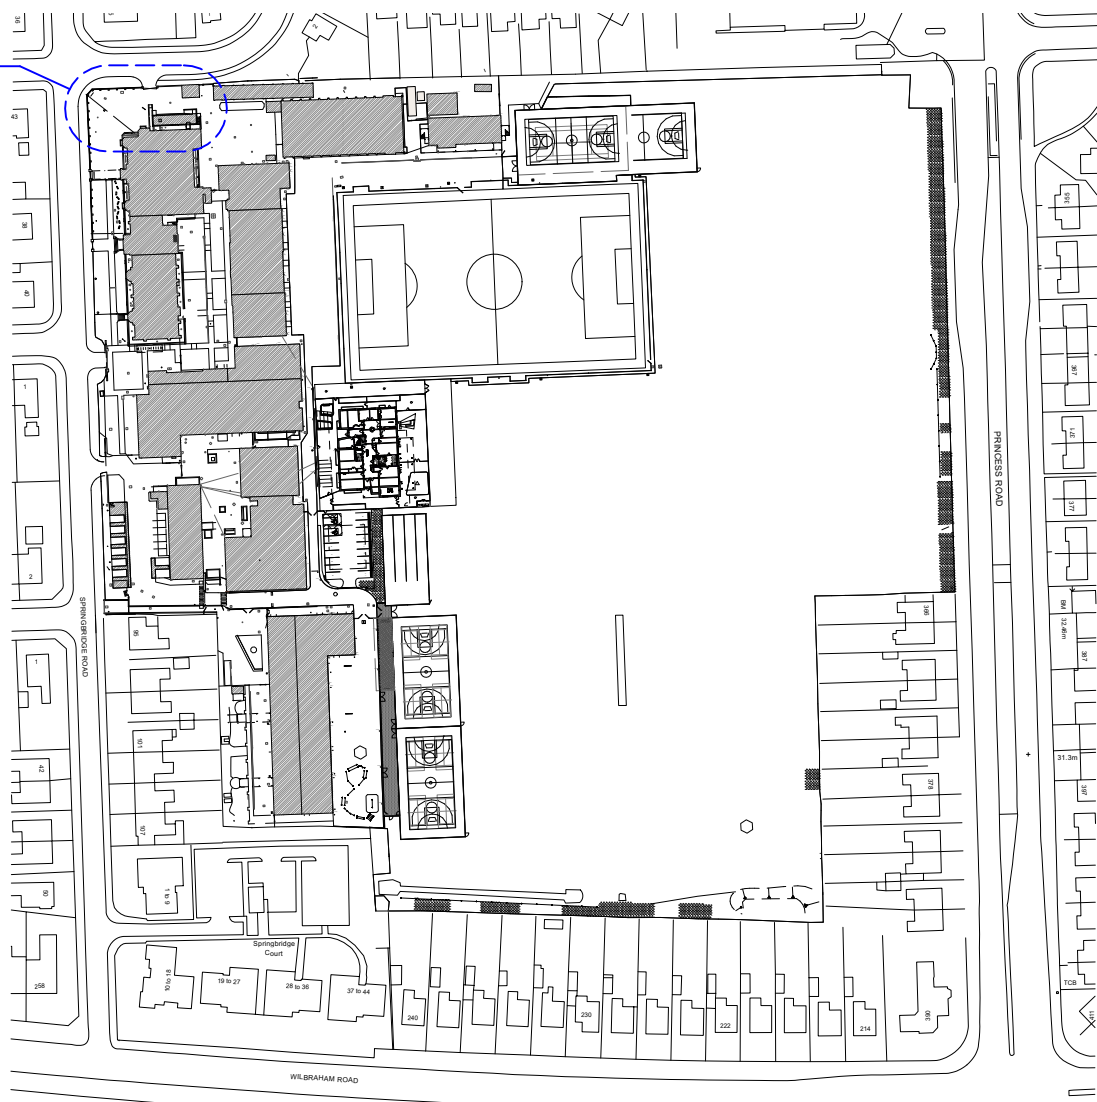

2 Site Plan
Scale: 1:2500

Site Plan and Project Brief

Proposed location on site

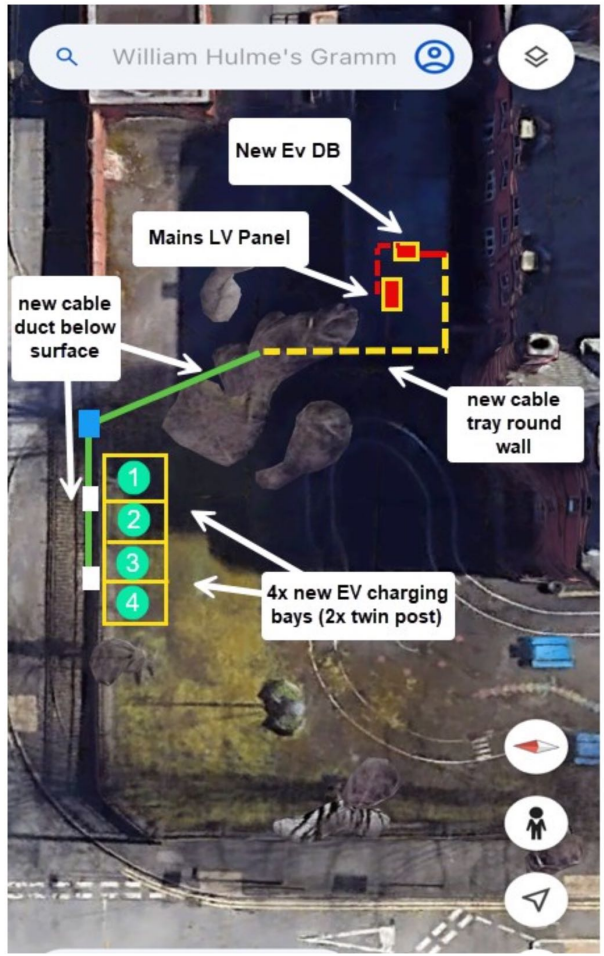

Hardware Specifications



AC Vestel Charger 7-22kWh enabled

Download here

P01 21/11/2025 Planning issue.
revisions

CoARC

COLLABORATIVE ARCHITECTURE

coarc.co.uk 0121 769 2414 studio@coarc.co.uk

project title
SPECIALLY RESOURCED PROVISION (SRP) BUILDING

client
UNITED LEARNING

project address
WILLIAM HULME'S GRAMMAR SCHOOL

drawing title
PROPOSED SITE PLAN EV CHARGING POINTS

PLANNING

scale
As noted @A3

date
10/11/2025

drawing no.
WHGS-COA-XX-00-D-A-0022

revision
P01

All dimensions to be checked & verified on site. Dimensions structural unless noted otherwise. Drawings to be read in conjunction with specification. Any bracketed dimensions are for checking and not for setting out purposes. Any discrepancies with other project information, existing building or site features are to be reported to the Architect before commencement. Do not scale from printed drawings without checking with the architect. © CoARC Ltd. The contents of this drawing may not be reproduced in whole or in part without express permission of CoARC Ltd