


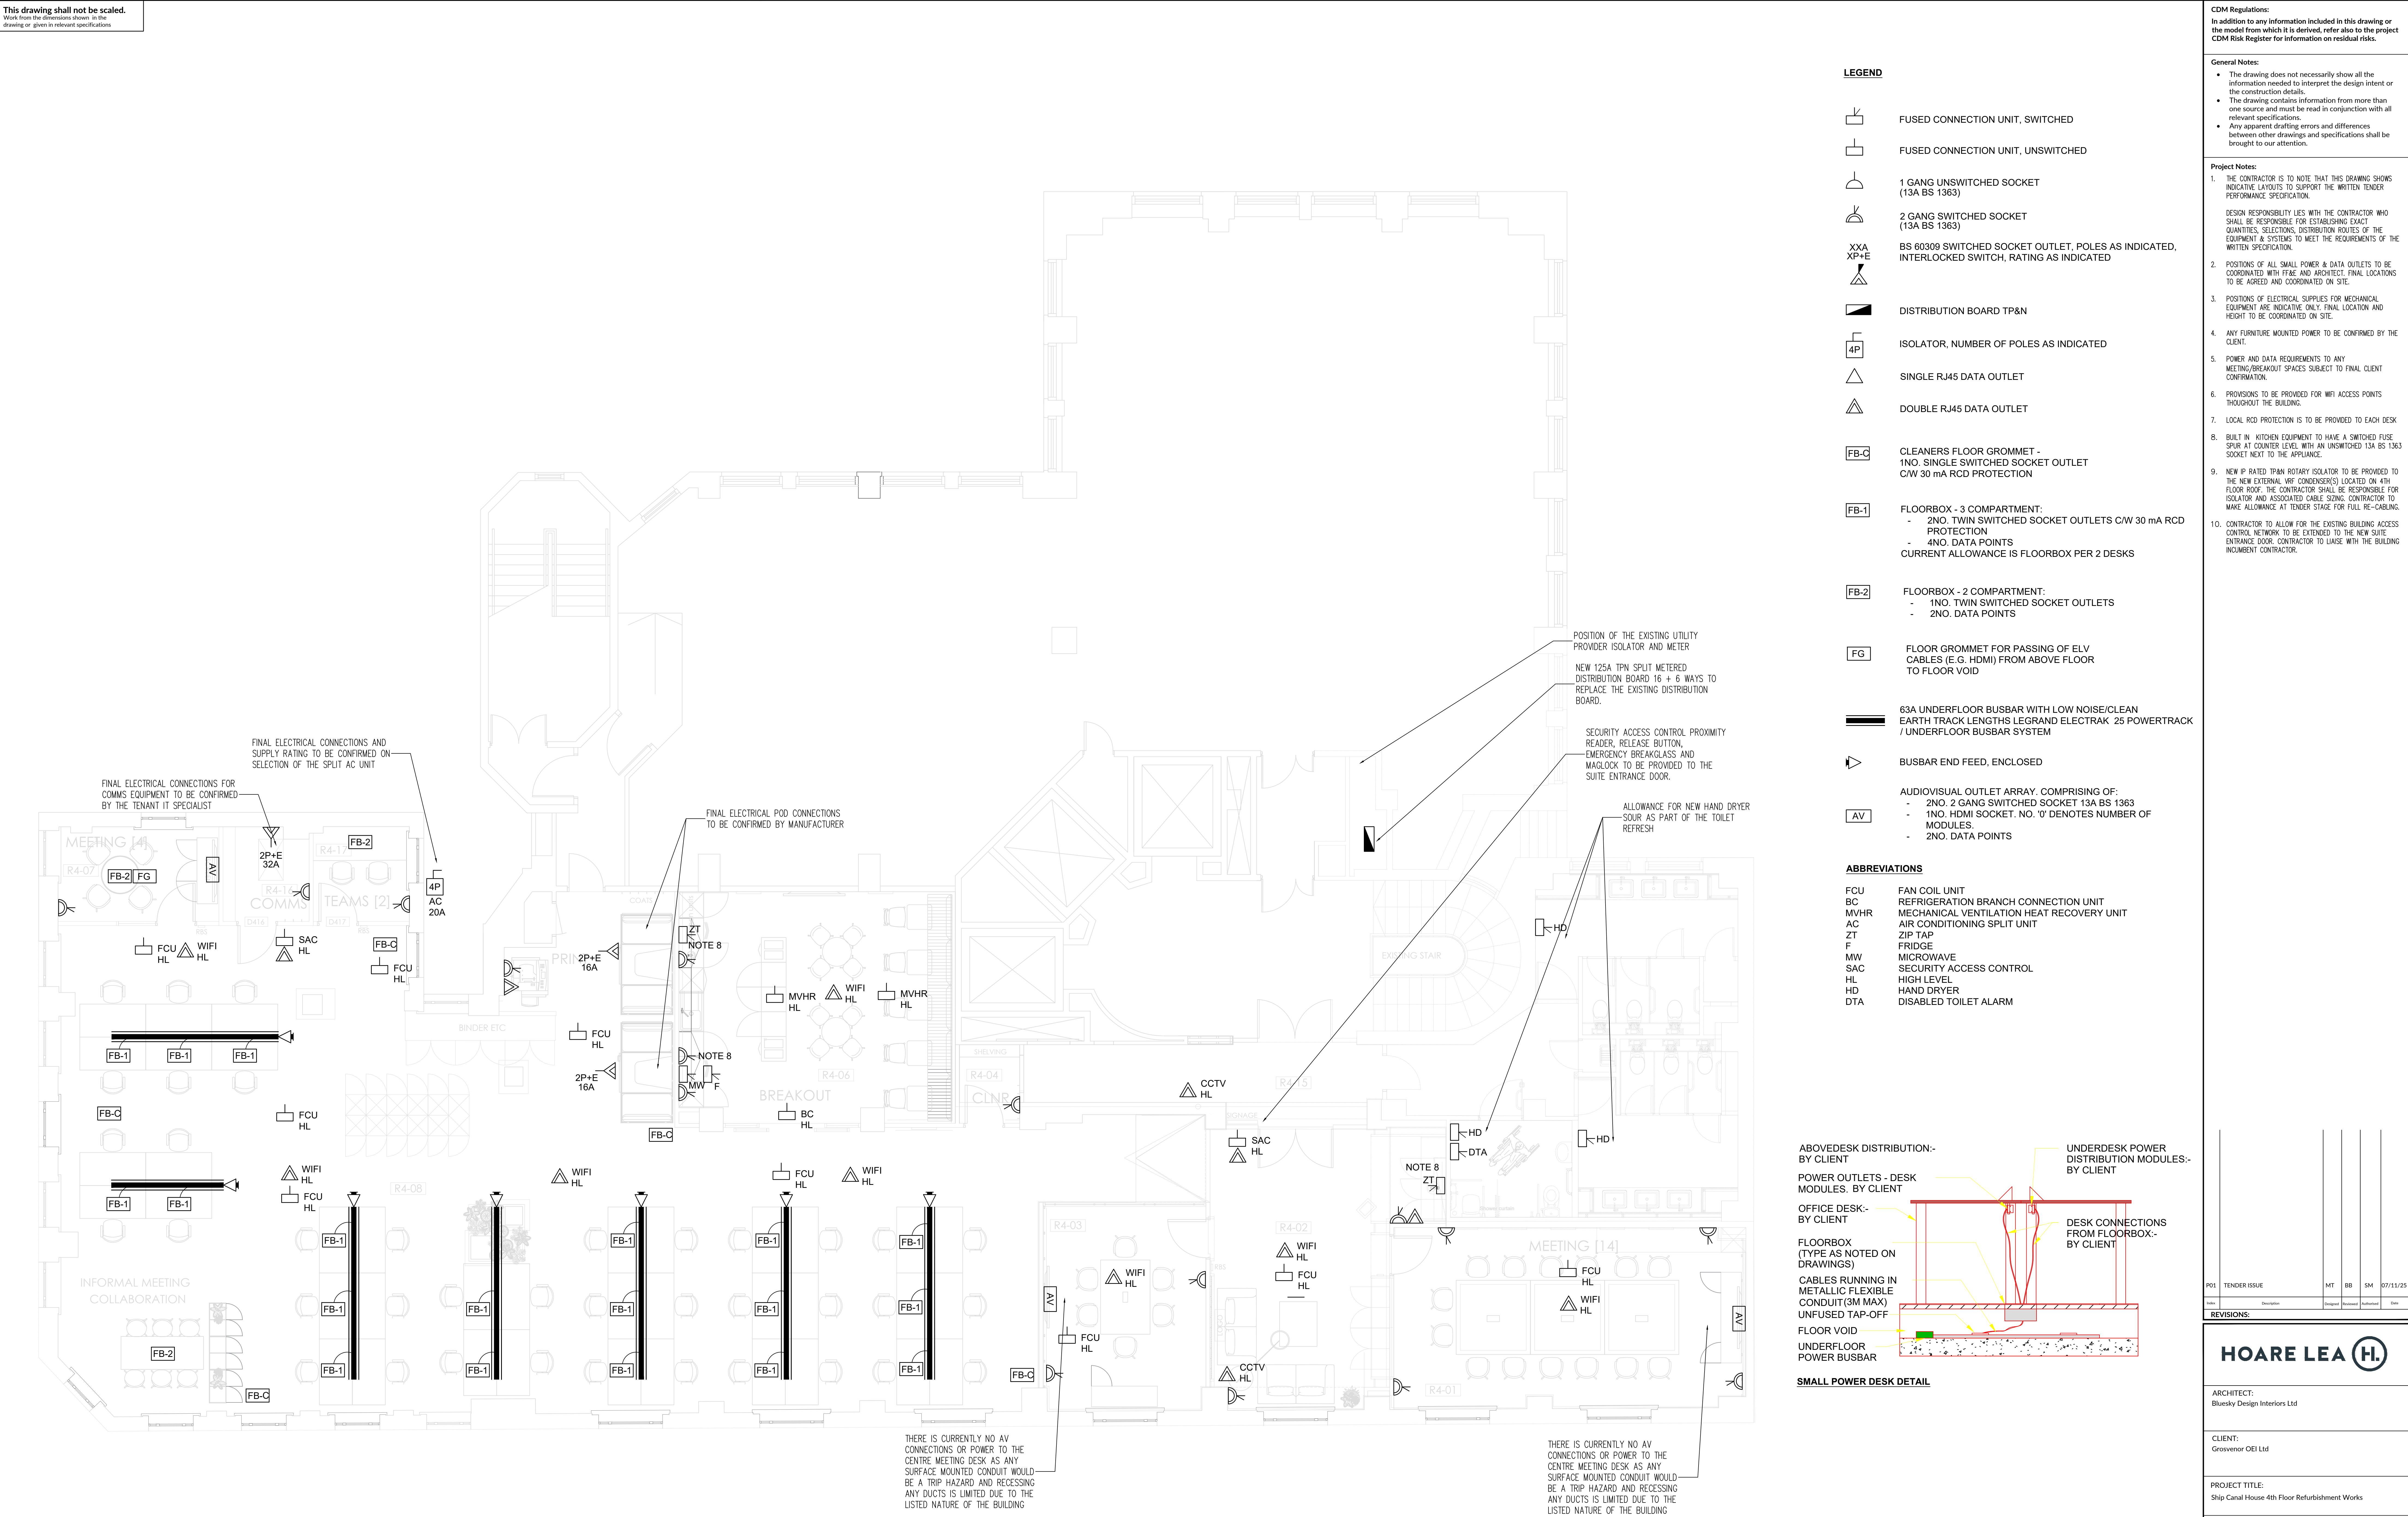

GENERAL ARRANGEMENT

CDM Regulations:
In addition to any information included in this drawing or the model from which it is derived, refer also to the project CDM Risk Register for information on residual risks.

- General Notes:**
- The drawing does not necessarily show all the information needed to interpret the design intent or the construction details.
 - The drawing contains information from more than one source and must be read in conjunction with all relevant specifications.
 - Any apparent drafting errors and differences between other drawings and specifications shall be brought to our attention.

- Project Notes:**
- THE CONTRACTOR IS TO NOTE THAT THIS DRAWING SHOWS INDICATIVE LAYOUTS TO SUPPORT THE WRITTEN TENDER PERFORMANCE SPECIFICATION.
 - DESIGN RESPONSIBILITY LIES WITH THE CONTRACTOR WHO SHALL BE RESPONSIBLE FOR ESTABLISHING EXACT QUANTITIES, SELECTIONS, DISTRIBUTION ROUTES OF THE EQUIPMENT & SYSTEMS TO MEET THE REQUIREMENTS OF THE WRITTEN SPECIFICATION.
 - POSITIONS OF ALL SMALL POWER & DATA OUTLETS TO BE COORDINATED WITH F&E AND ARCHITECT. FINAL LOCATIONS TO BE AGREED AND COORDINATED ON SITE.
 - POSITIONS OF ELECTRICAL SUPPLIES FOR MECHANICAL EQUIPMENT ARE INDICATIVE ONLY. FINAL LOCATION AND HEIGHT TO BE COORDINATED ON SITE.
 - ANY FURNITURE MOUNTED POWER TO BE CONFIRMED BY THE CLIENT.
 - POWER AND DATA REQUIREMENTS TO ANY MEETING/BREAKOUT SPACES SUBJECT TO FINAL CLIENT CONFIRMATION.
 - PROVISIONS TO BE PROVIDED FOR WIFI ACCESS POINTS THROUGHOUT THE BUILDING.
 - LOCAL RCD PROTECTION IS TO BE PROVIDED TO EACH DESK
 - BUILT IN KITCHEN EQUIPMENT TO HAVE A SWITCHED FUSE SPUR AT COUNTER LEVEL WITH AN UNSWITCHED 13A BS 1363 SOCKET NEXT TO THE APPLIANCE.
 - NEW IP RATED TYPAN ROTARY ISOLATOR TO BE PROVIDED TO THE NEW EXTERNAL WRF CONDENSER(S) LOCATED ON 4TH FLOOR ROOF. THE CONTRACTOR SHALL BE RESPONSIBLE FOR ISOLATOR AND ASSOCIATED CABLE SIZING. CONTRACTOR TO MAKE ALLOWANCE AT TENDER STAGE FOR FULL RE-CABLING.
 - CONTRACTOR TO ALLOW FOR THE EXISTING BUILDING ACCESS CONTROL NETWORK TO BE EXTENDED TO THE NEW SUITE ENTRANCE DOOR. CONTRACTOR TO LIASE WITH THE BUILDING INCUMBENT CONTRACTOR.

PO1 TENDER ISSUE

MT BB SM 07/11/25

REVISIONS:

HOARE LEA

ARCHITECT:
Bluesky Design Interiors Ltd

CLIENT:
Grosvenor OEI Ltd

PROJECT TITLE:
Ship Canal House 4th Floor Refurbishment Works

DRAWING TITLE:
Small Power & Data Layout

PRELIMINARY ISSUE

PERSON RESPONSIBLE FOR:

Design: MT Review: BB Authorising Issue: SM

Project No: 17/18784 Date: 07/11/25 Scale @ A0: 1:100

DRAWING NUMBER: 791-E1718784-HLEA-XX-04-DR-E-700001 Status: S3 Rev: P01

PRELIMINARY ISSUE