


01 SUITE 8.2 FLOOR PLAN
008.2 SCALE - 1:100 @ A1
AS EXISTING

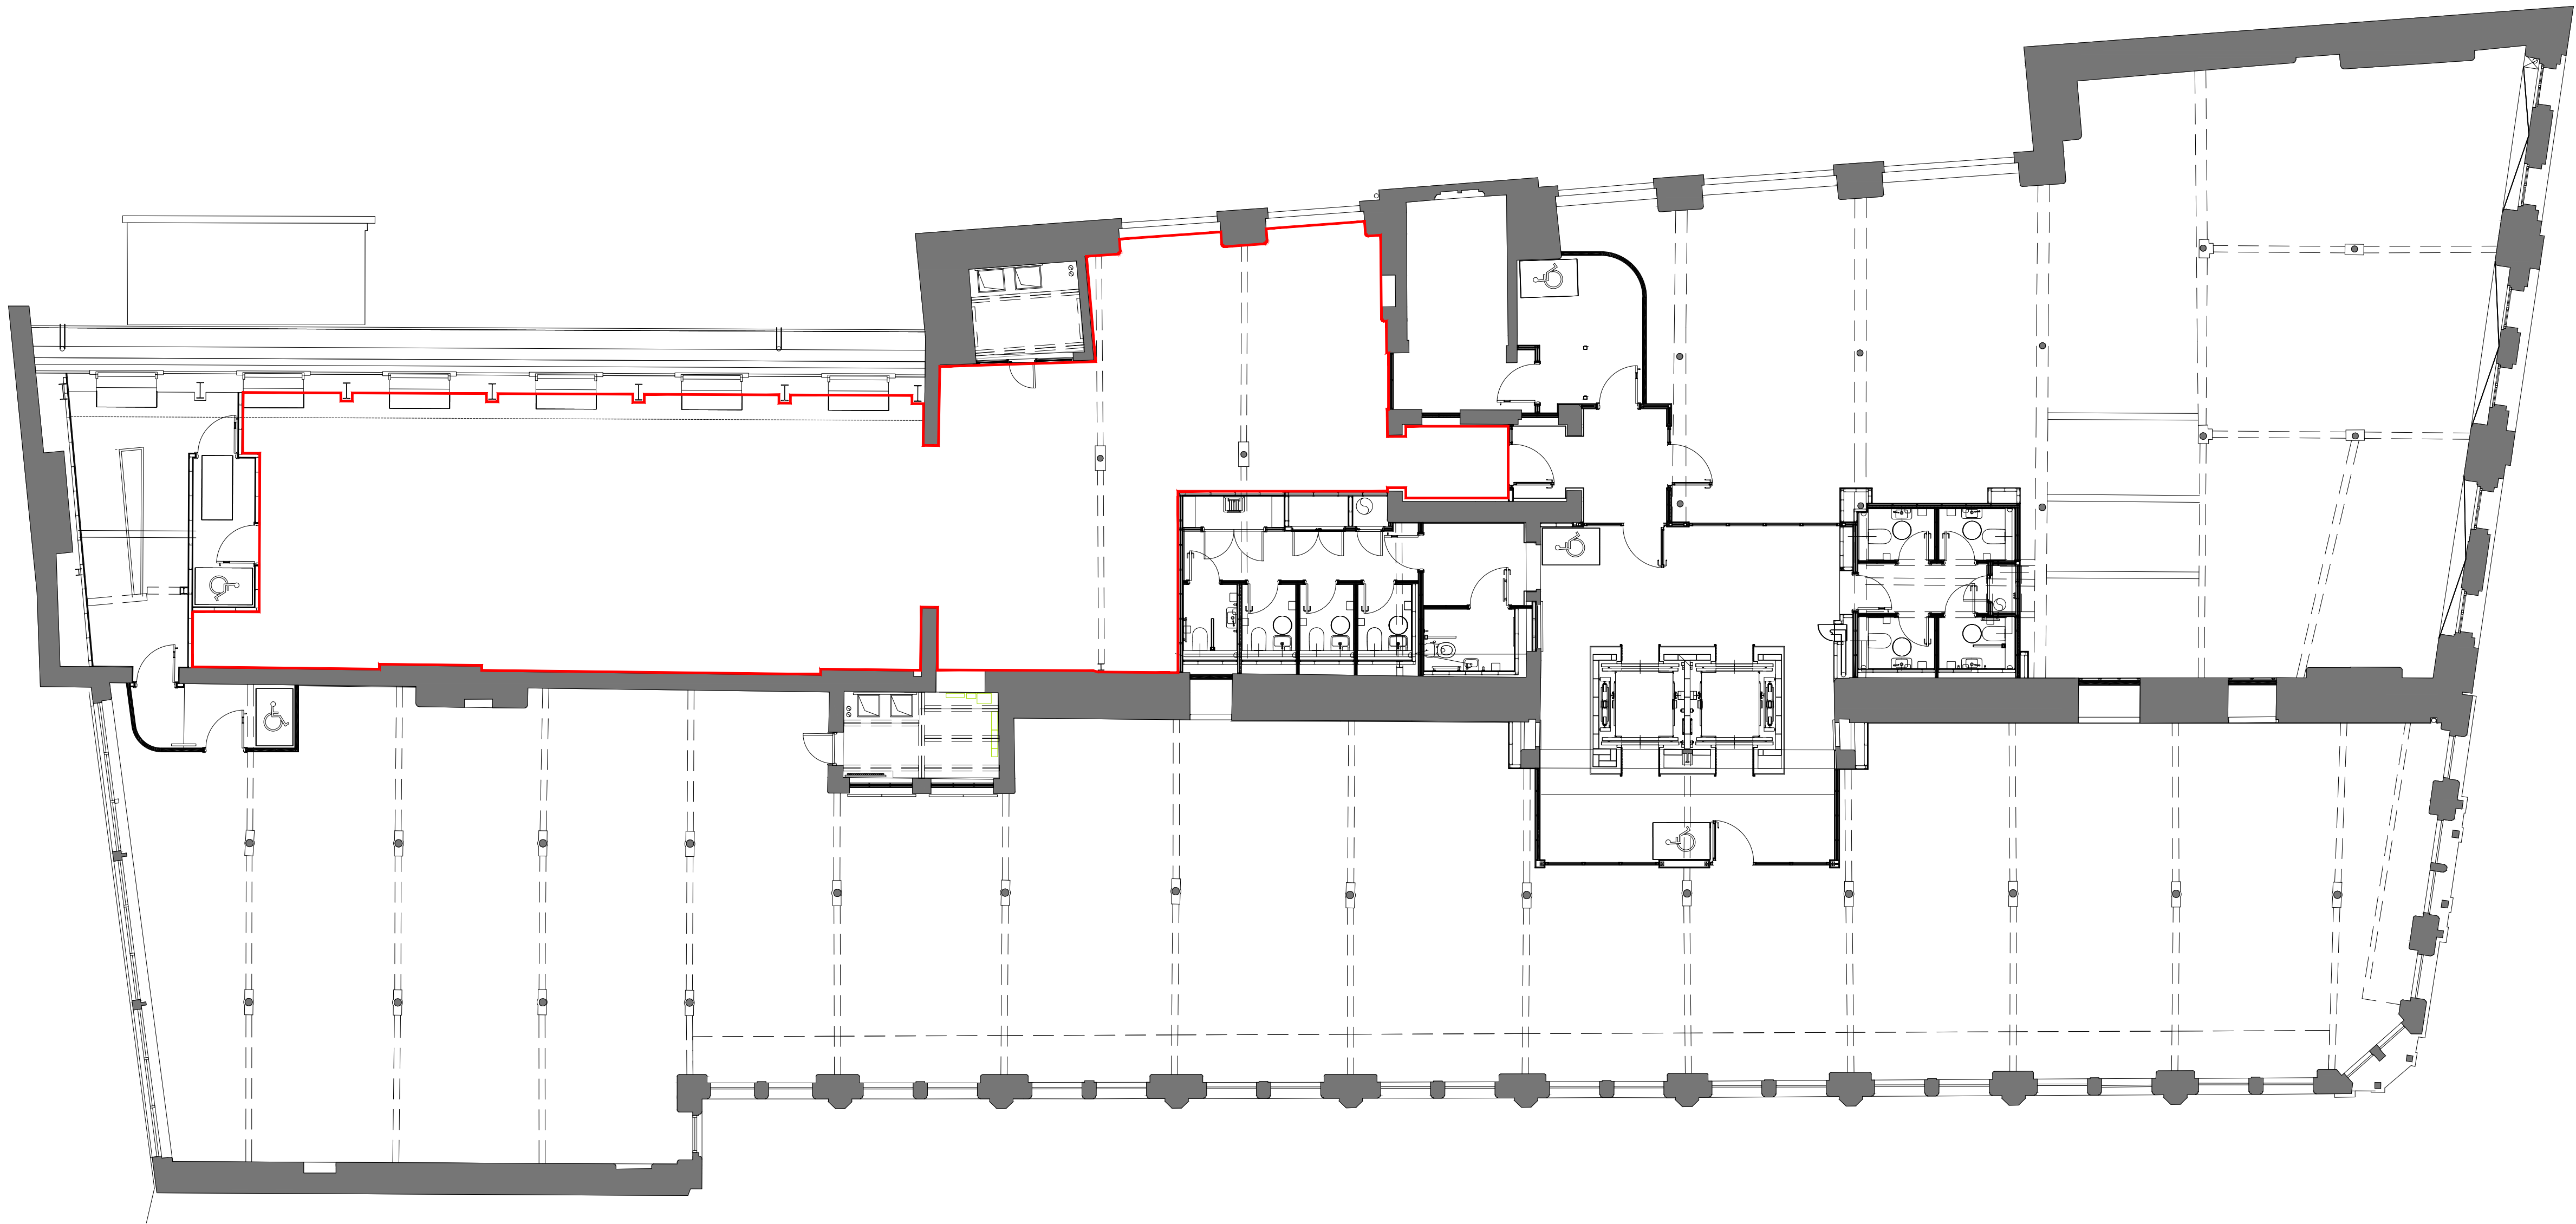

NOTES

DO NOT SCALE FROM THIS DRAWING.
ALL DIMENSIONS TO BE CHECKED ON SITE.
(DRAWINGS MAYBE SCALED FOR LOCAL AUTHORITY & PLANNING PURPOSE ONLY)
COPYRIGHT PROTECTED.

0 0.5 1.0 2.0 3.0 4.0 5.0m

Scale 1:100

FOR PLANNING
DO NOT USE FOR CONSTRUCTION

CONSULTANT REFERENCES IN DRAWING:

STRUCTURAL - REF/REVISION

GENERAL NOTES:

THE CONTRACTOR IS NOT TO SCALE FROM THIS DRAWING BUT FOLLOW THE WRITTEN FINISHED DIMENSIONS. ANY DISCREPANCIES BETWEEN THE DRAWING AND THE OTHER CONTRACT DOCUMENTS OR ANY DISCREPANCIES WITHIN A DRAWING OR BETWEEN DRAWINGS MUST BE REPORTED IMMEDIATELY TO THE ARCHITECT.

THE CONTRACTOR IS TO INSPECT THE SITE PRIOR TO TENDER AND IS RESPONSIBLE FOR STRIPPING OUT IN ACCORDANCE WITH THE DRAWINGS ENSURING THAT THE WORK IS UNDERTAKEN SAFELY.

THE CONTRACTOR WILL BE RESPONSIBLE FOR THE SETTING OUT OF THE WORKS.

CONTRACTOR IS TO ALLOW FOR ALL FIRE STOPPING THROUGH WALLS, CEILINGS AND FLOORS.

THE ELECTRICAL INSTALLATION IS TO BE IN ACCORDANCE WITH THE CURRENT EDITION OF THE IEE REGULATIONS AND ALL CABLING TO BE LSF.

THE CONTRACTOR IS RESPONSIBLE FOR THE DETAILED SERVICES DESIGN INCLUDING LOADINGS, CABLE AND PIPEWORK ROUTES AND PIPEWORK / CABLE SIZING AND SPECIFICATION. ALL CABLE TRAY, MS CONDUIT AND OTHER SERVICES ARE TO BE EXPOSED BELOW SLAB/ CEILINGS.

ANY H&V PROPOSAL IS INDICATIVE ONLY AND THE SPECIALIST CONTRACTOR IS TO BE RESPONSIBLE FOR THE DETAIL DESIGN & ALL SWITCH/ SOCKET OUTLETS TO COMPLY WITH CLIENT'S STANDARD SPECIFICATION.

NOTE - ALL EXISTING FIRE RESISTING ENCLOSURES TO SERVICE RISERS TO BE MAINTAINED OR MADE GOOD WHERE DISTURBED. NEW AND EXISTING CABLES, PIPES AND DUCTS PASSING THROUGH FIRE RESISTING CONSTRUCTION TO BE ADEQUATELY FIRE STOPPED. NEW AND EXISTING DUCTWORK PASSING THROUGH FIRE RESISTING CONSTRUCTION TO HAVE FIRE DAMPERS.

WALL AND CEILING LININGS MUST ACHIEVE A MINIMUM FIRE CLASSIFICATION OF EUROCLASS C-S3, D2 OR HIGHER WITHIN GENERAL ROOMS.
WALL AND CEILING LININGS MUST ACHIEVE EUROCLASS B-S3, D2 OR HIGHER WITHIN CIRCULATION AREAS (WALLCOVERINGS WHICH CONFORM TO BS EN 15102, ACHIEVING AT LEAST CLASS C-S3, D2 AND BONDED TO A CLASS A2-S3, D2 SUBSTRATE, WILL ALSO BE ACCEPTABLE).

CONTRACTORS AND SUPPLIERS OF SPECIALIST JOINERY/EQUIPMENT MUST ENSURE ALL TIMBER MATERIALS RECEIVE FIRE RETARDANT TREATMENT TO ACHIEVE A MINIMUM EUROCLASS RATING OF B-S1,D0 (OR EQUIVALENT). MEDIUM-DENSITY FIBREBOARD (MDF) MUST ALSO MEET THIS FIRE PERFORMANCE CLASSIFICATION THROUGH APPROPRIATE TREATMENT OR SELECTION OF COMPLIANT PRODUCTS

CONTRACTOR AND SUPPLIERS OF SPECIALIST EQUIPMENT TO PROVIDE FIRE RATING CERTIFICATES FOR ALL SPECIALIST LININGS AND LAMINATES TO BE USED FOR NWR APPROVAL.

ALL PAINTS TO BE WATER BASED

ALL DIMENSIONS TO BE CHECKED ON SITE PRIOR TO ANY MANUFACTURE OR CONSTRUCTION OF EQUIPMENT, FINISH, SIGNAGE ETC.

3.00	12/11/25	ISSUED FOR PLANNING	CC	ARB
REV	DATE	DESCRIPTION	DRAWN	CHECKED

A × I

ADDRESS : 4th FLOOR CALICO 53-55 MOSLEY STREET,
MANCHESTER, M2 3HQ
TELEPHONE : +44 (0)161 879 7357
EMAIL : www.axi.studio
COMPANY No : 11847325

CLIENT



PROJECT

**40 PRINCESS STREET,
MANCHESTER
M1 6DE**

DRAWING REFERENCE

**EX-08.2-EIGHTH FLOOR PLAN
AS EXISTING**

JOB REFERENCE	DRAWING SCALE	DATE	DRAWN	CHECKED
25 - 292	1:100 @ A1		CC	FE
DRAWING REFERENCE	STAGE	REV		
AX1 - 00.82	3	00		