



Notes:
Drawings are based on survey data and may not accurately represent what is physically present.
Do not scale from this drawing. All dimensions are to be verified on site before proceeding with the work.
All dimensions are in millimeters unless noted otherwise.
Purcell shall be notified in writing of any discrepancies.

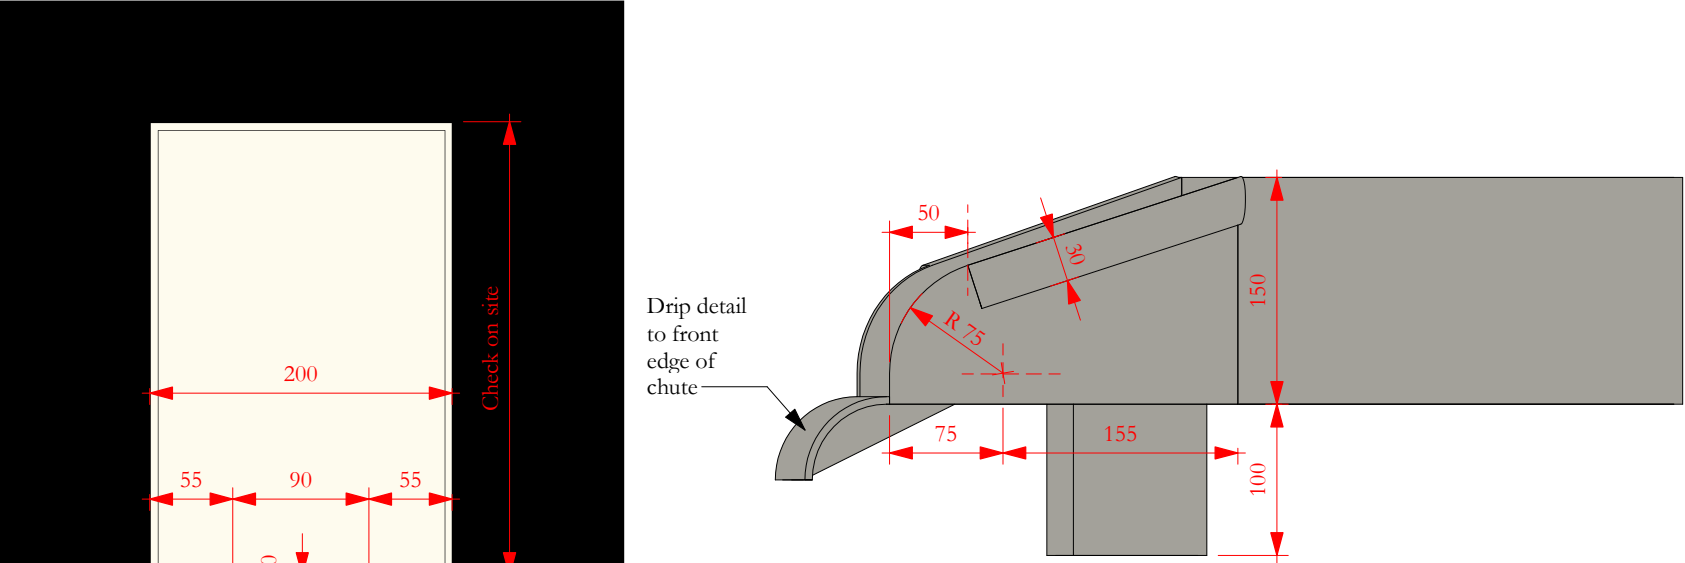


Side elevation on angle side

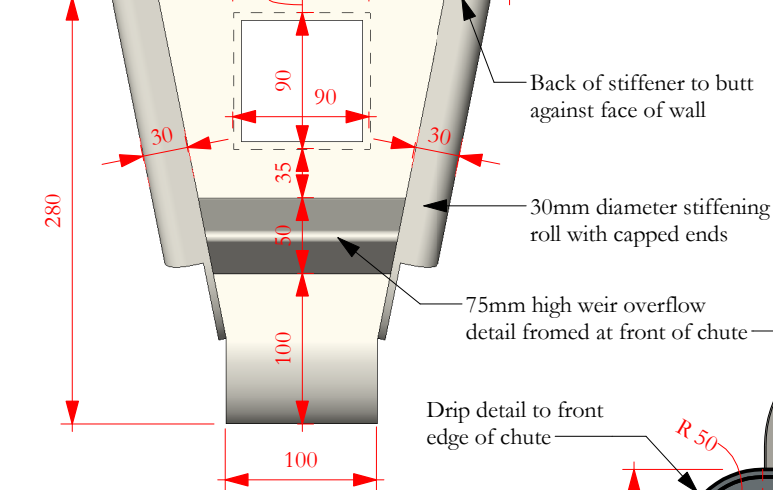


Plan

Folded reinforcing detail welded below drip detail. Edge of reinforcing section set 10mm from outside edge of drip

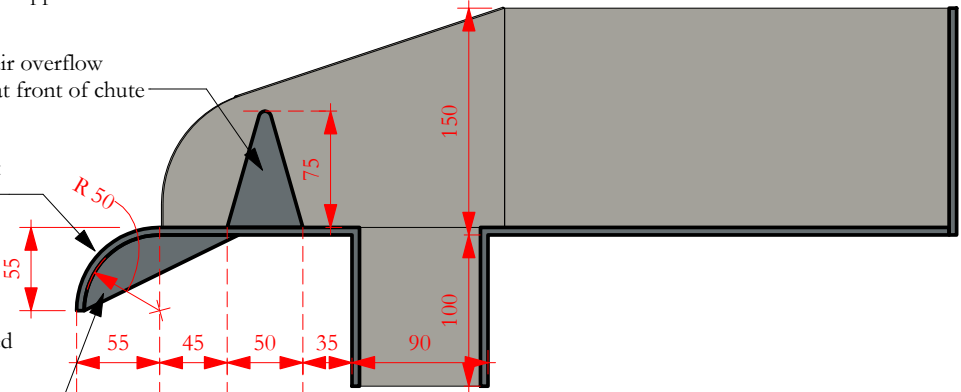


Section

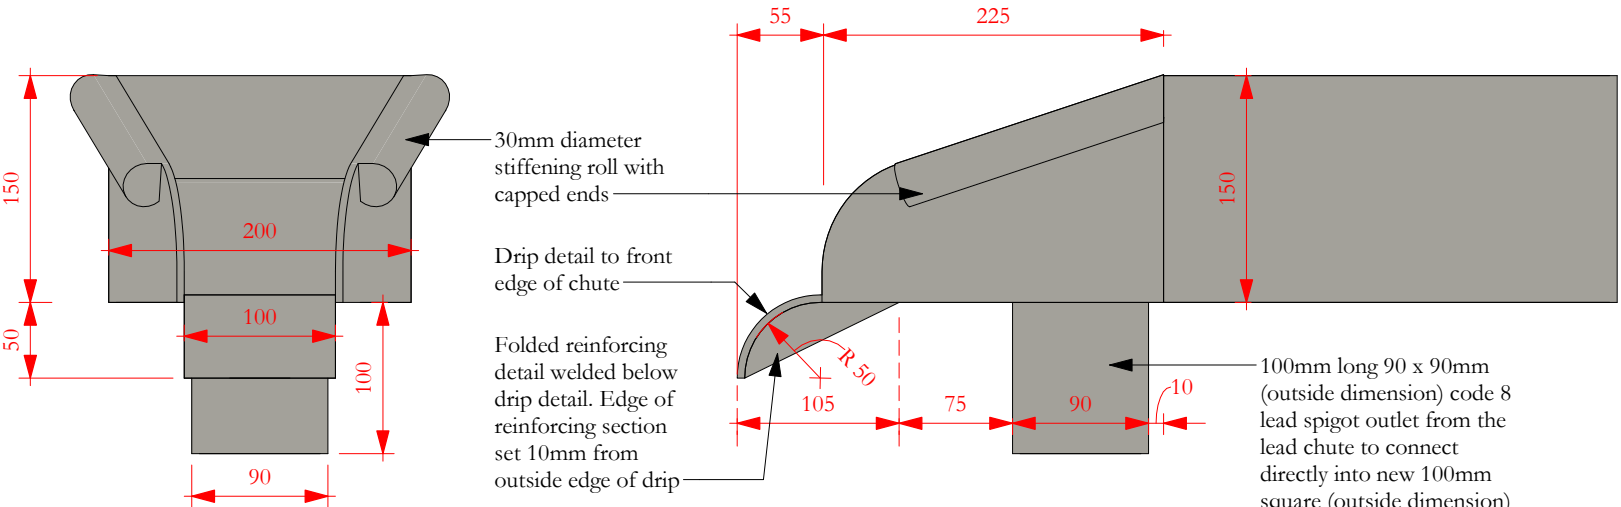

Front Elevation

Side Elevation

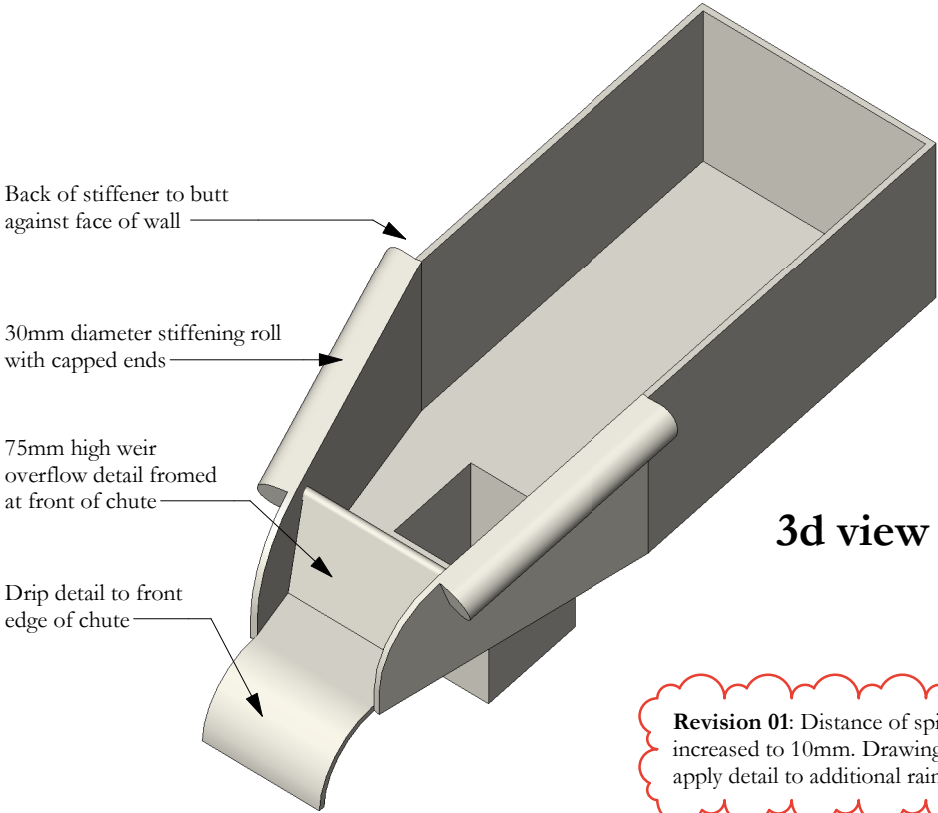

3d view

Lead chute to be fabricated from code 8 lead sheet. The main body of the chute is to be formed from one sheet of lead with folded and bossed details to front and side and welded joints to concealed corners on the rear face

Revision 01: Distance of spigot outlet from wall increased to 10mm. Drawing title amended to apply detail to additional rainwater pipe outlets

ISSUE	DATE	APPROVED	DRAWN	DESCRIPTION
01	31/05/2024	JC	GR	See note in revision cloud
	06/06/2023	JC	GR	First issue



Project Office, Town Hall, Manchester M60 2L1
+44 (0) 7970 097 432
www.purcelluk.com

PROJECT STATUS **RIBA stage 5**

CLIENT **Manchester City Council**

PROJECT **Our Town Hall**

DRAWING TITLE **Lead chute for rainwater pipes RWP 16.1, RWP 17.1 and RWP 24.1**

SIZE & SCALE **[A3] 1 : 5**

DRAWING STATUS **S4 Construction**

JOB NUMBER **236959**

DRAWING NO. **OTH-PUR-TH-RF-DWG-A-7000** REV **01**