


GROSVENOR | 4TH FLOOR SHIP CANAL HOUSE, MANCHESTER

WASHROOM CEILINGS / LIGHTING LAYOUT

This drawing is the property of Bluesky Design Interiors Limited and must not be copied or otherwise reproduced. All dimensions must be checked on site before commencing work. This drawing was produced using AutoCAD 2025.

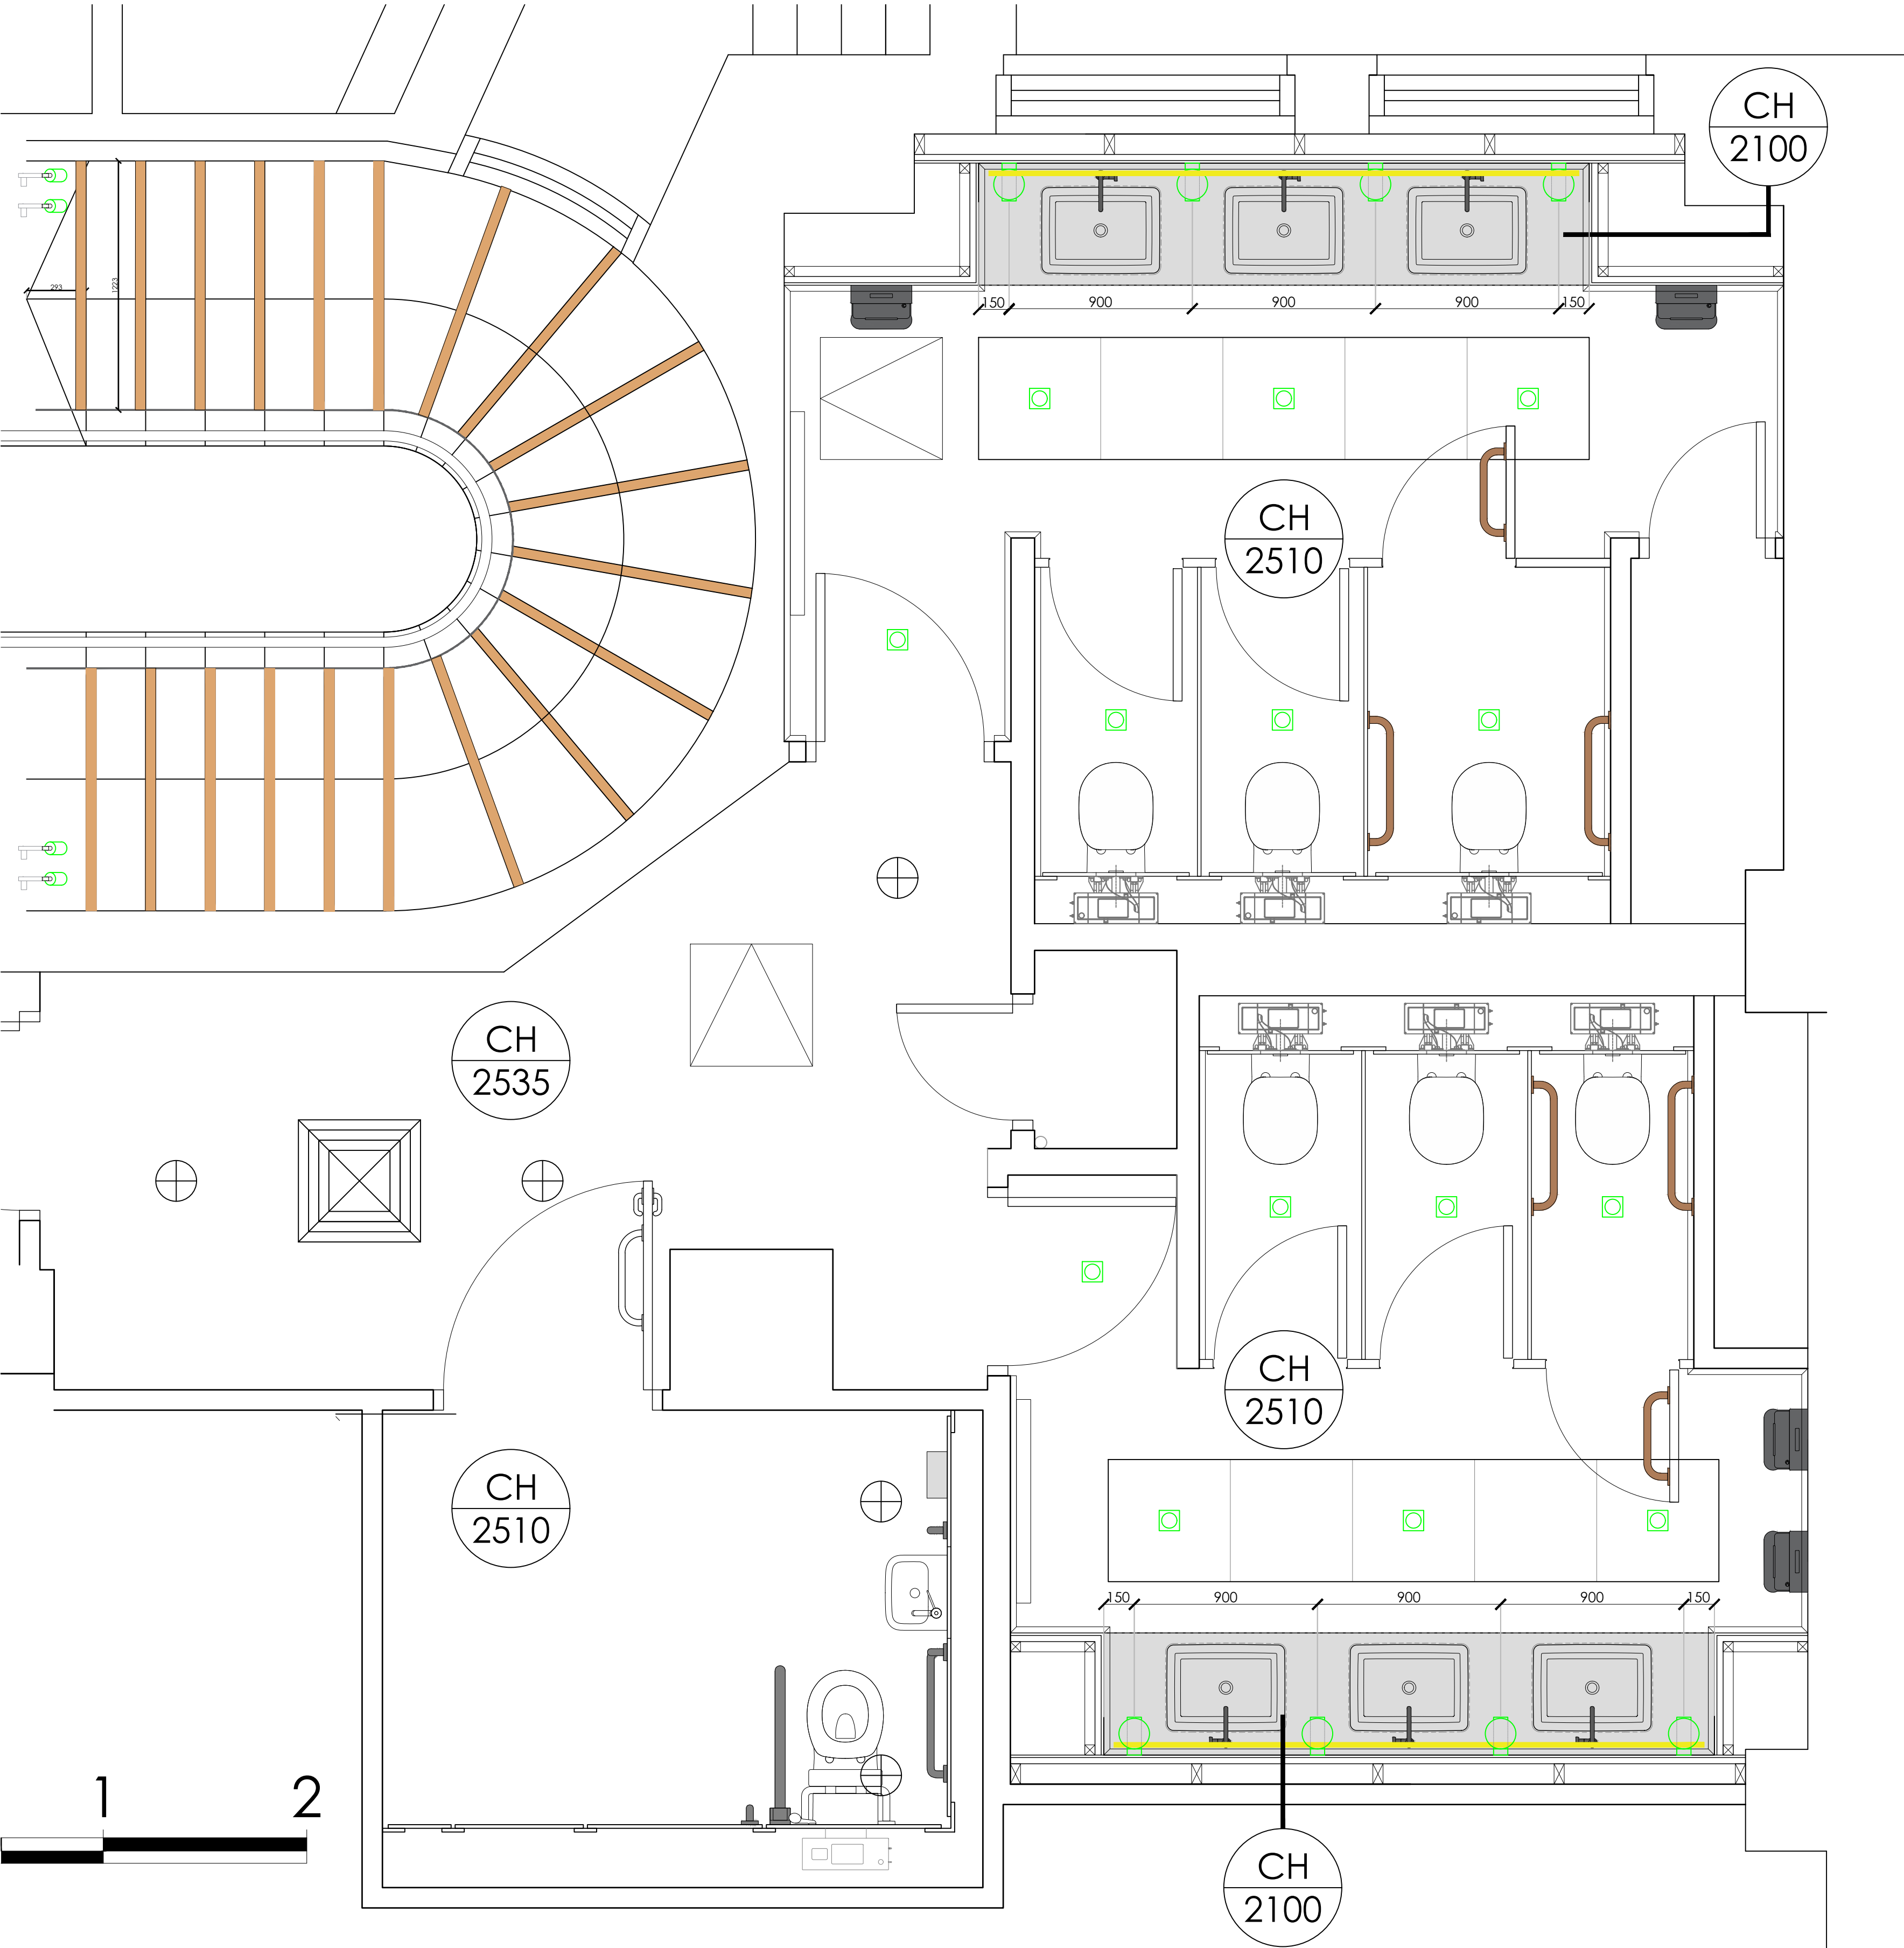

FEATURE CEILINGS KEY

Existing MF and plasterboard ceiling to receive new paint finish to match existing
Colour:- White RAL 9010

New MF and plasterboard skimmed bulkhead above vanity to receive paint finish.
See 1308-0X-WC-01 for details

New 600x600 moisture resistant ceiling tiles to replace existing
Colour:- White RAL 9010

CH
2510

Indicates ceiling height
Exact heights to existing ceilings T8C on site
Height varies between floors

Existing access hatches to be replaced like for like
Colour:- White RAL 9010

FEATURE LIGHTING KEY

TYPE 1 - WALL LIGHT
Manufacturer: Deltalight
Type: Oono W S - Wall mounted IP54
Colour: Black
Size: Ø150 x D186mm
See 04-WC-01/02 for setting out

TYPE 2 - DOWNLIGHT
Manufacturer: Deltalight
Type: Entero SQ M fixed downlight
Colour: Black
Size: W100 x D100

TYPE 3 - LED LIGHT STRIP
LED light strip with diffuser built into bulkhead above vanity units
See section detail 04-WC-01&02

TYPE 4 - EXISTING DOWNLIGHT
Existing downlights to be retained

NOTES:
M&E LIGHTING CONSULTANT TO APPROVE ALL LIGHTING LEVELS AND POWER OUTPUTS.
FOR FULL M&E PROPOSALS, REFER TO M&E CONSULTANTS SPECIFICATION FOR ALL SERVICES RUNS, LIGHTING & ELECTRICAL LAYOUTS
THIS DRAWING SHOWS LIGHTING DESIGN INTENT ONLY FOR FEATURE LIGHTING SETTING OUT TO BE COORDINATED WITH M&E CONSULTANT'S LAYOUT

B	07.09.25	Lighting type numbers indicated	HEK
A	27.6.25	FIRST FULL ISSUE FOR COMMENT	FLC
Rev	Date	Description	By
Client		GROSVENOR	
Project		4TH FLOOR SUITE	
Address		SHIP CANAL HOUSE	
Drawing Title		WASHROOM CEILINGS / LIGHTING	
Date		26.06.2025	
Scale		1:20 @ A1	
By		FLC	
Drawing No		1427-04-WC-05(B)	
Status		FOR COMMENT	