



CRUMPSALL VALE CARE CENTRE 131.44 kWp
(Export Limitation - 88kW)

This drawing contains proprietary information belonging to Revolution Energy Services Ltd and may not wholly or partially be reproduced nor disclosed without prior written permission of Revolution Energy Services Ltd
DO NOT SCALE FROM THIS DRAWING

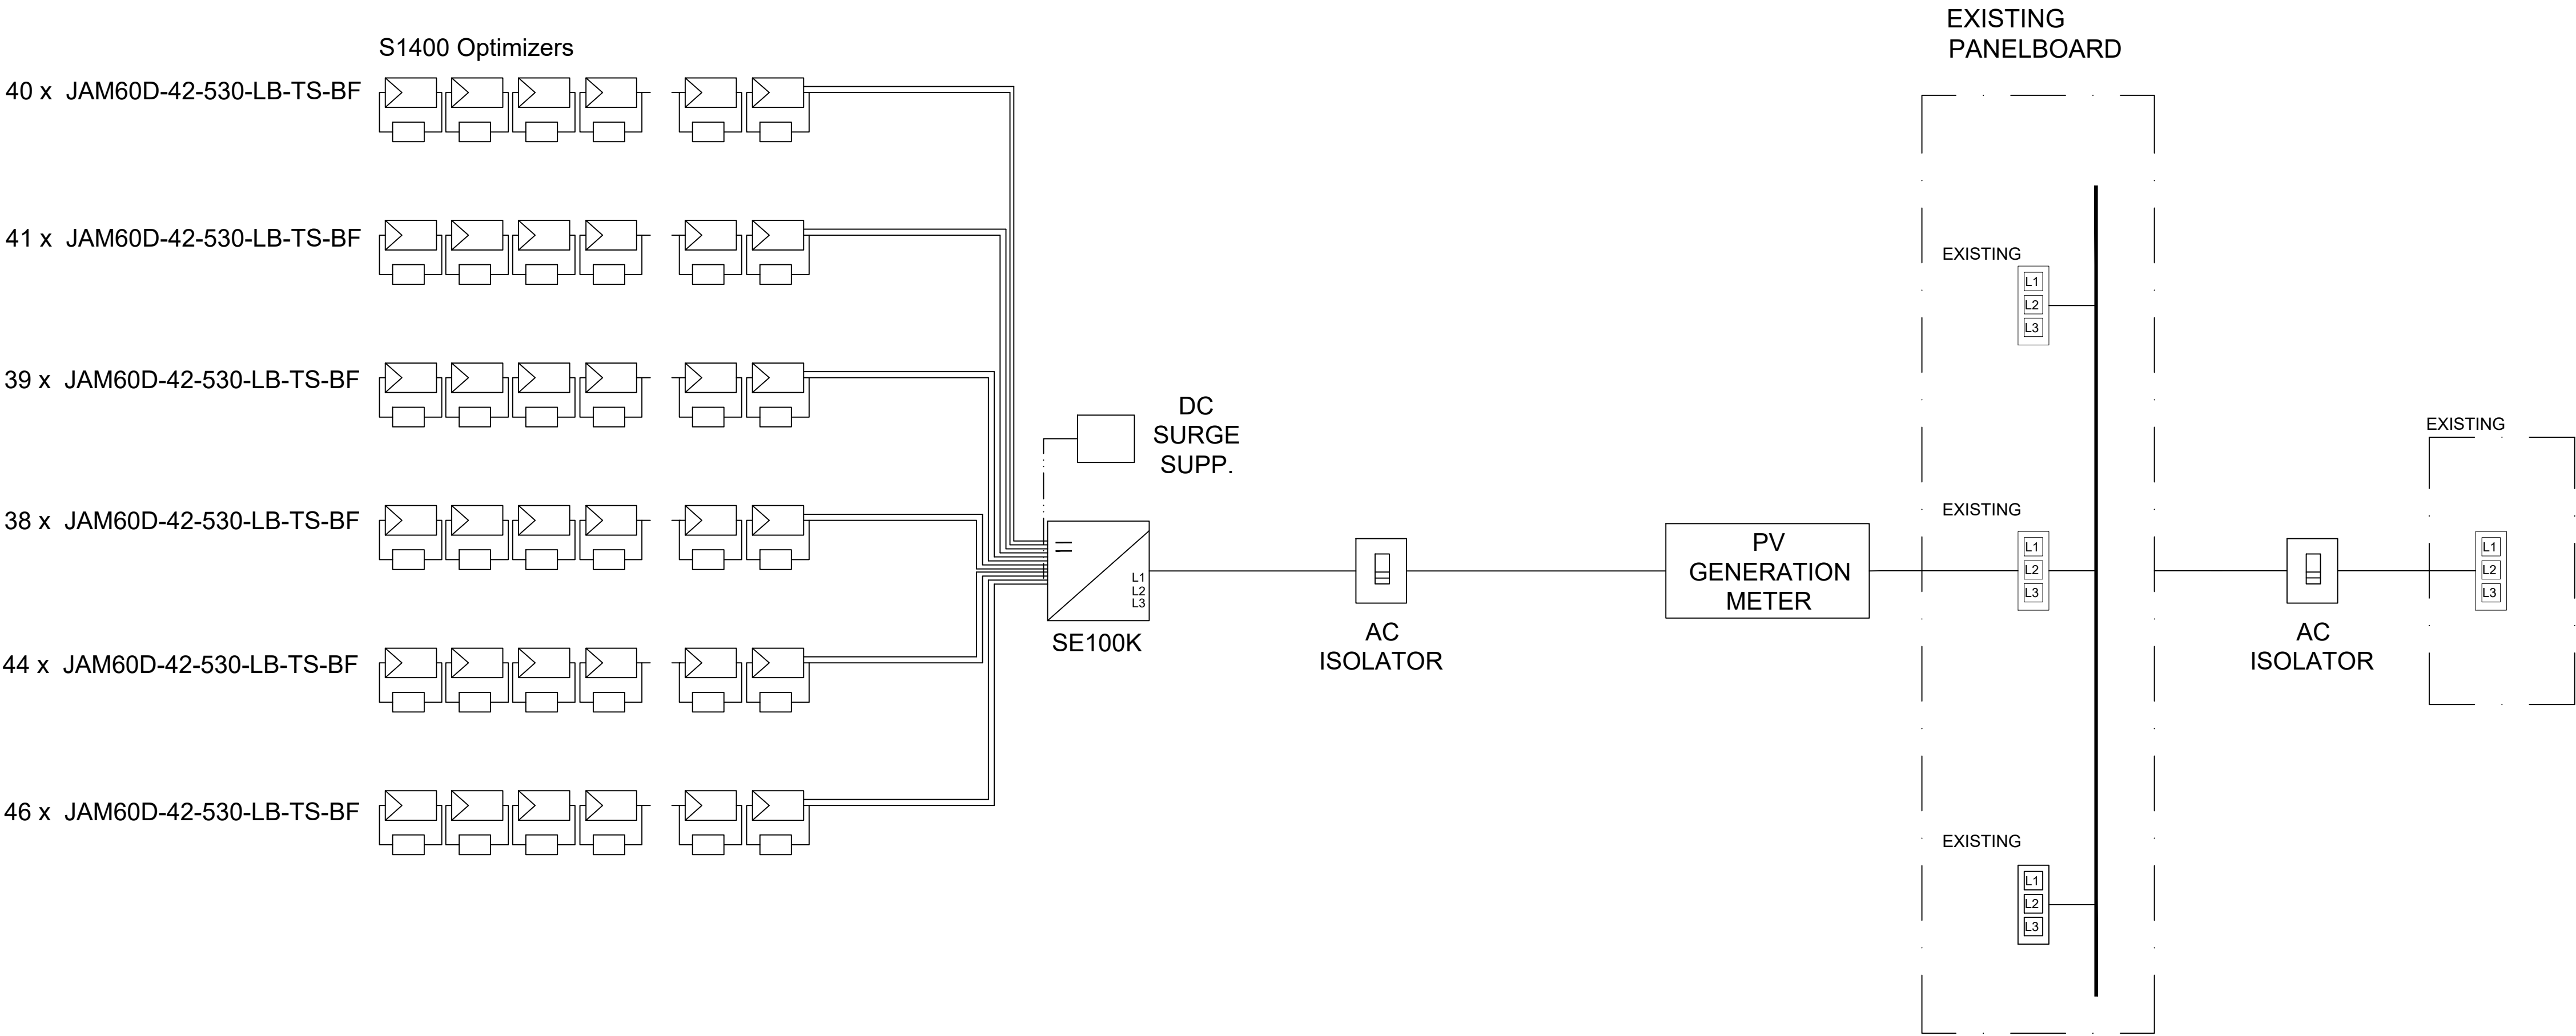

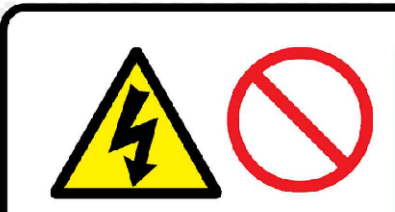

WARNING
Dual Supply

Isolate on-site generator at

Isolate mains supply at

Do not work on this equipment until it is isolated from both mains and on-site generation supplies.

Revisions:

Rev	Date	Comments	Drawn
00	05.25	FIRST ISSUE	CB

Client: CRUMPSALL VALE CARE CENTRE
Location: CRUMPSALL VALE CARE CENTRE MANCHESTER

Title: PV SINGLE LINE DIAGRAM

Drawn: RES
Scale: NTS@A1
Drawing No: RES00349-1

Checked: AM
Date: 27/05/25
Rev: 00

Do not scale from this drawing. Site verify all dimensions prior to construction. Report all discrepancies to the drawing originator immediately. This drawing is to be read in conjunction with all relevant documents and drawings.