




Plan

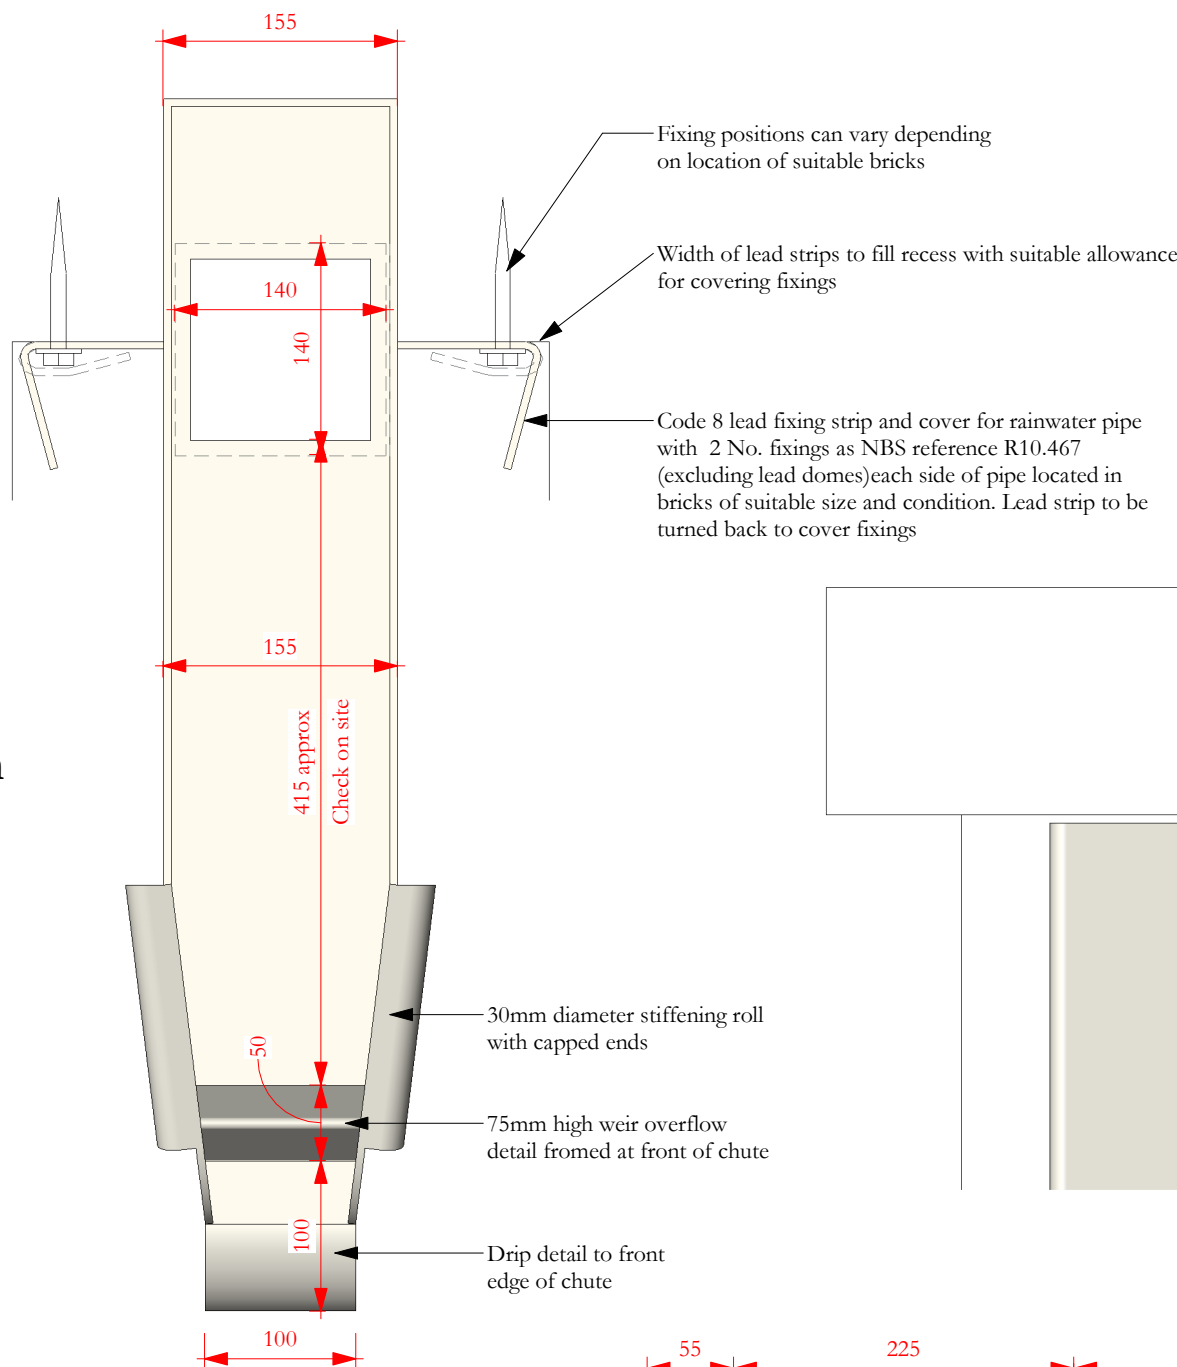


Front Elevation

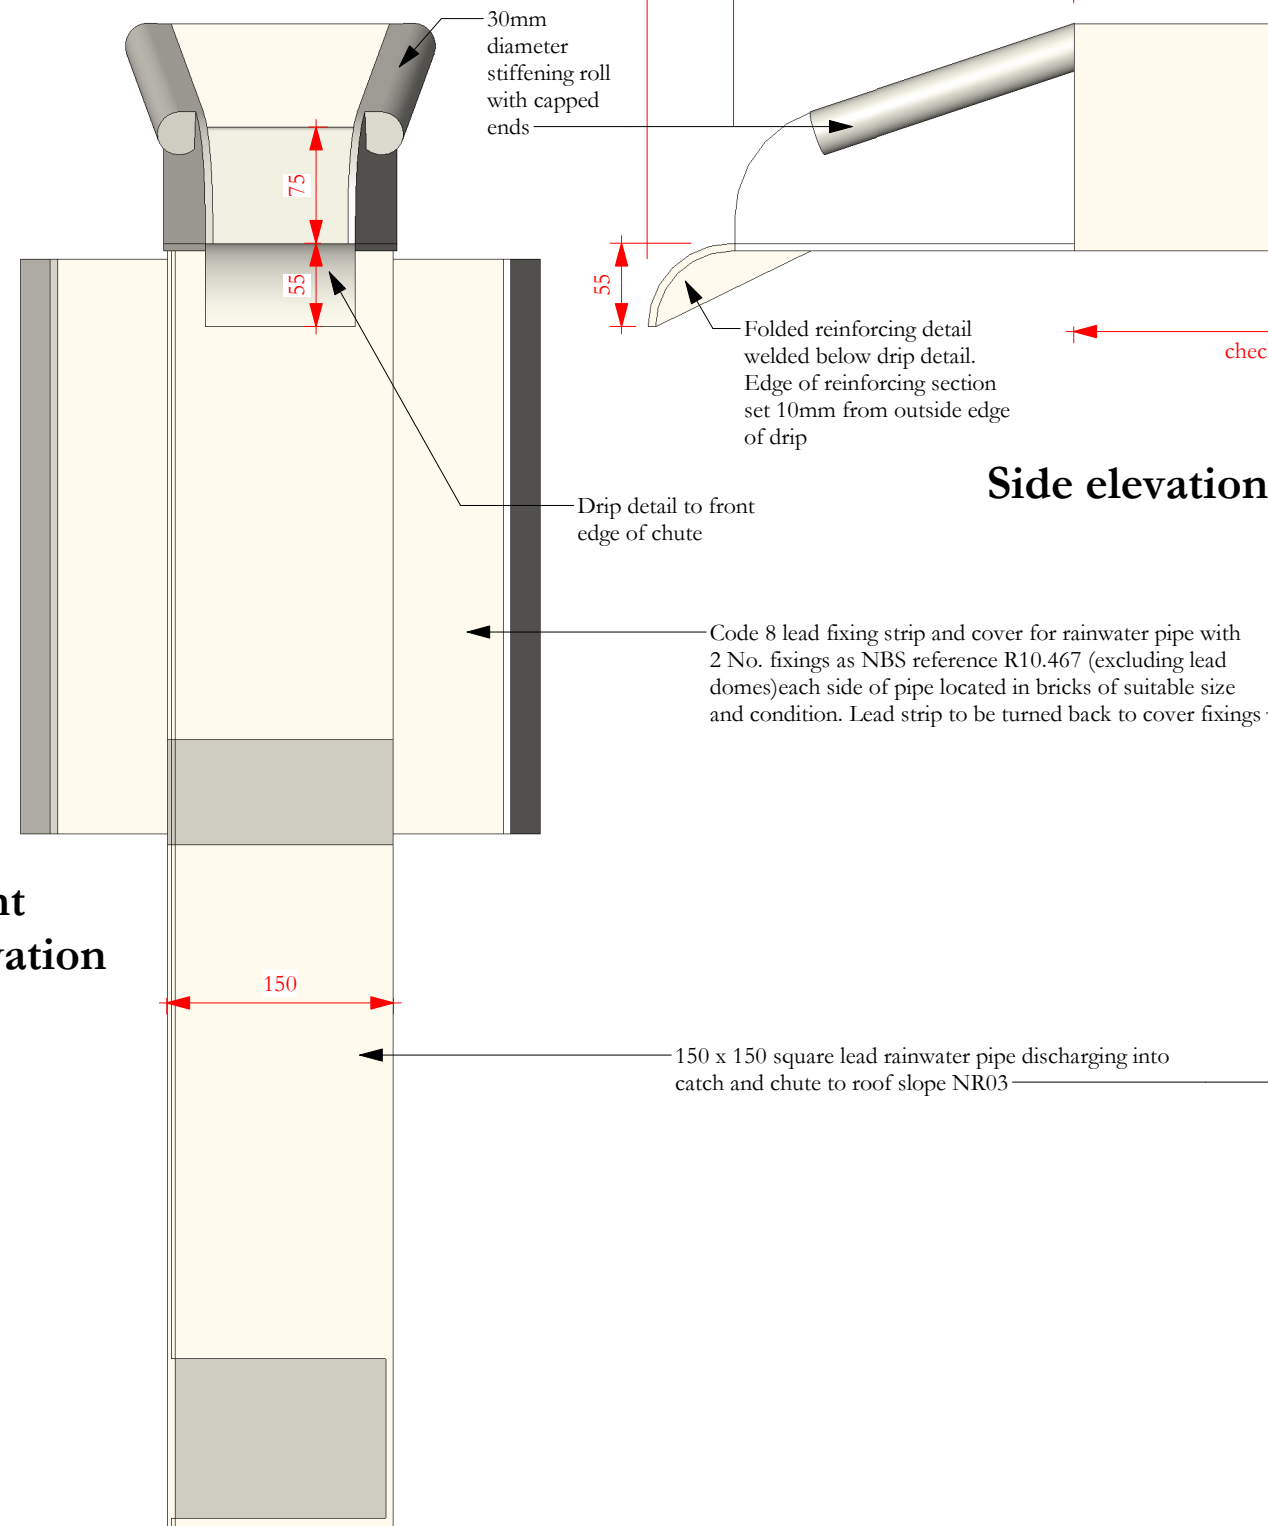


Elevation parallel with tapered side

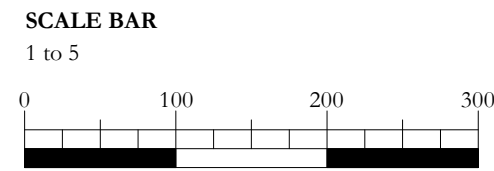


Side elevation

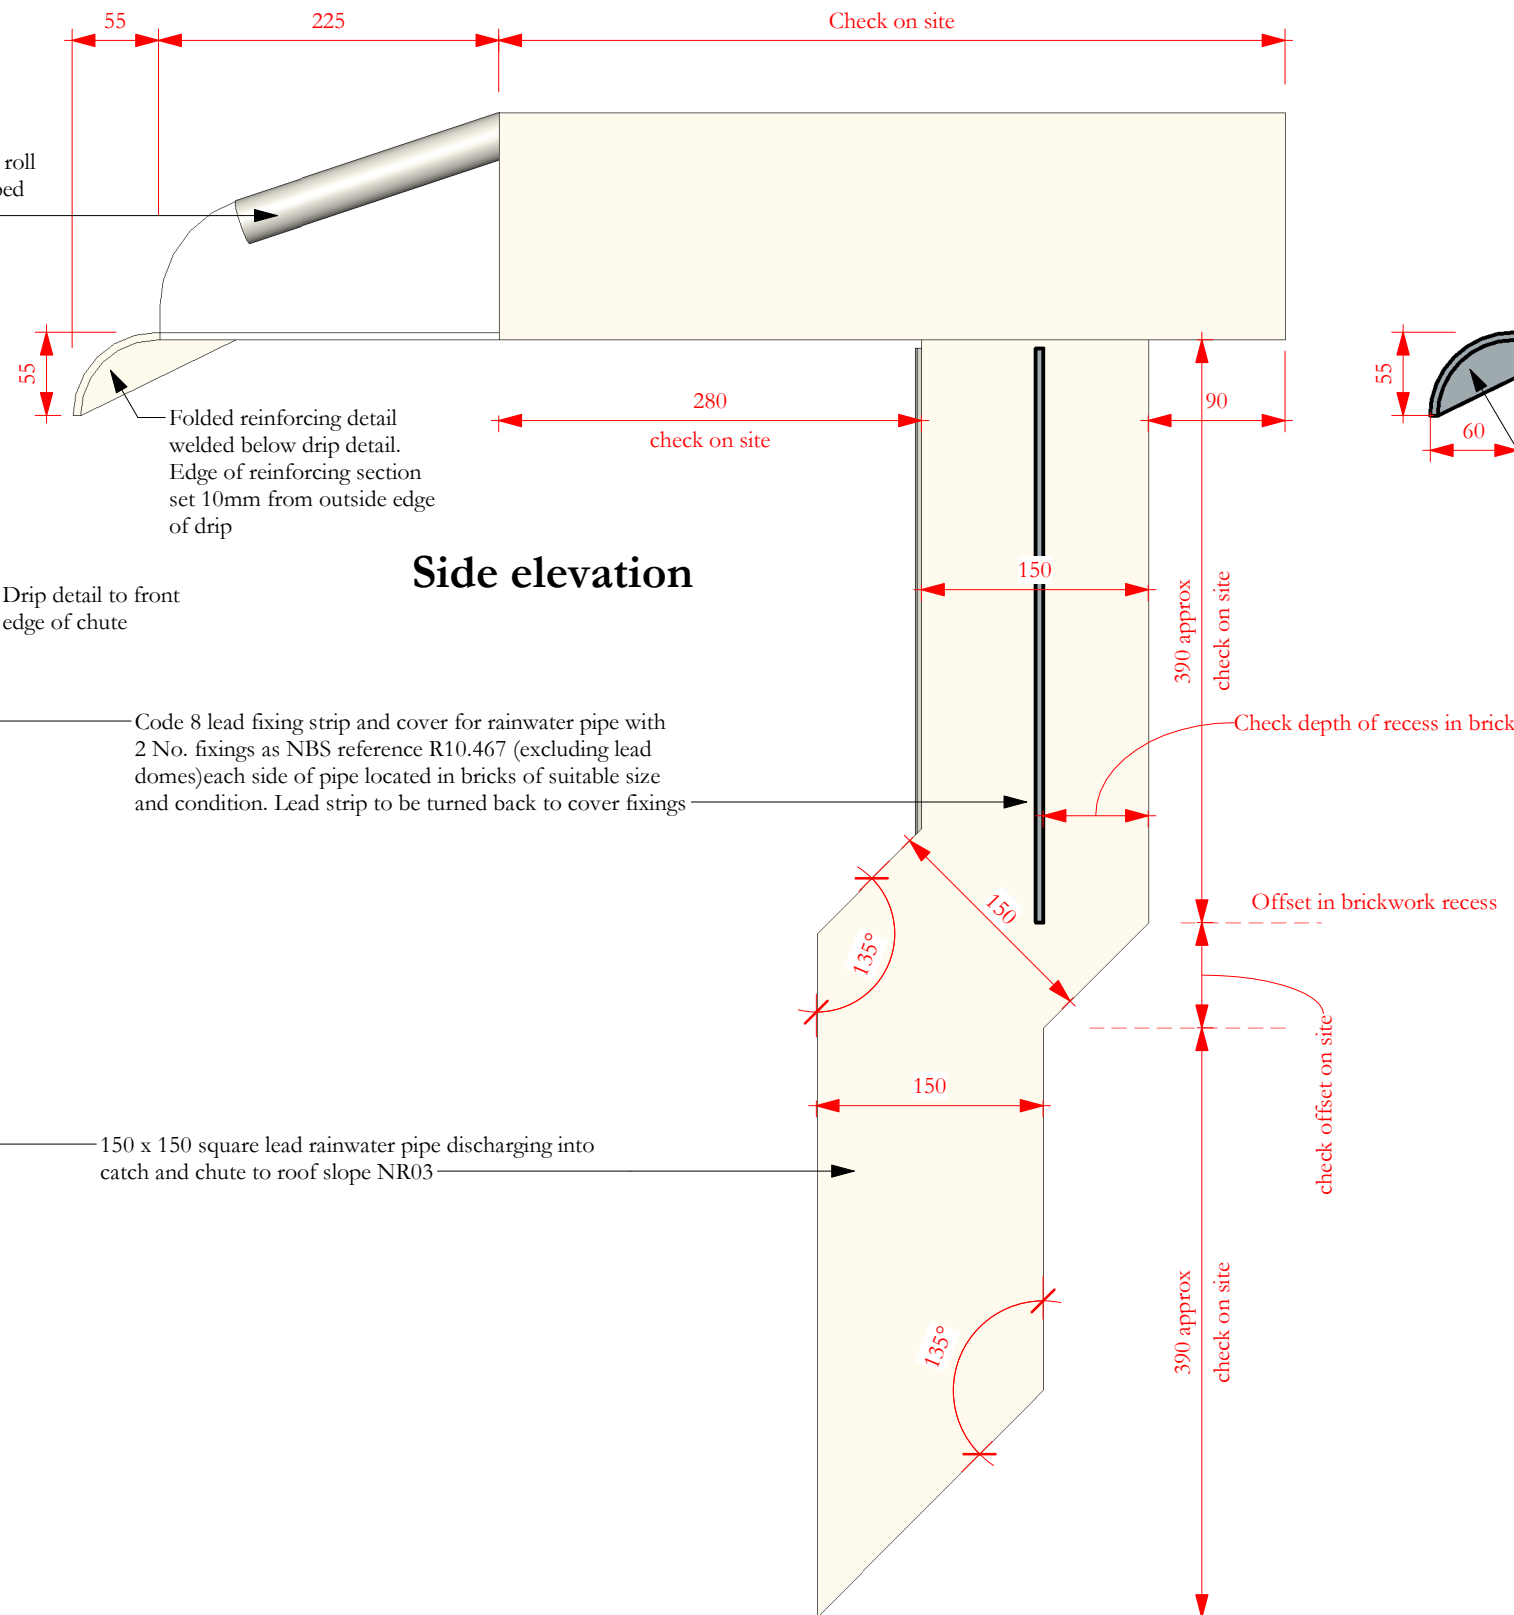

3d view

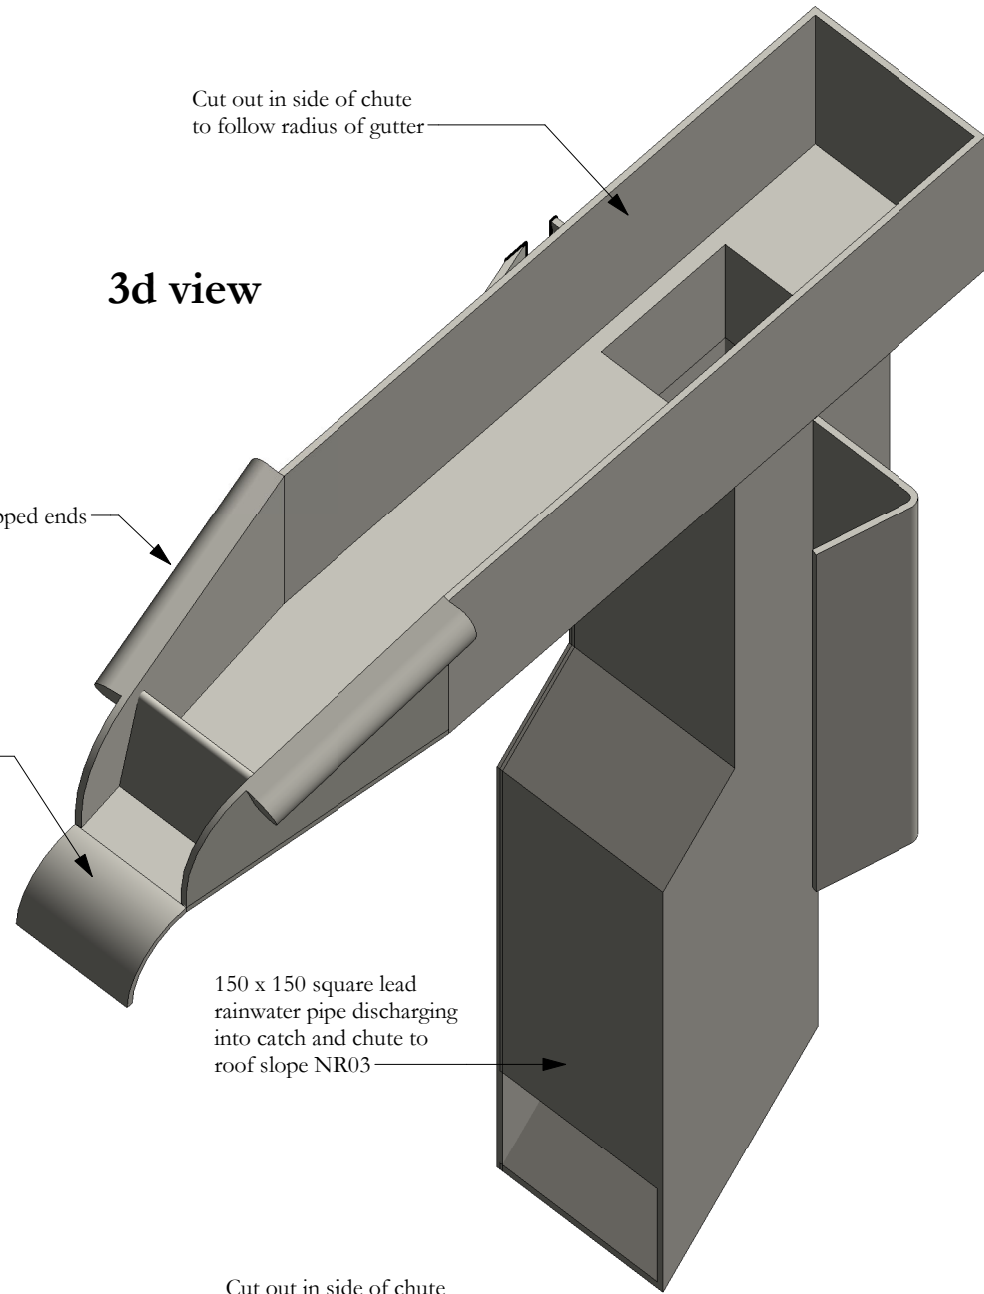

Section

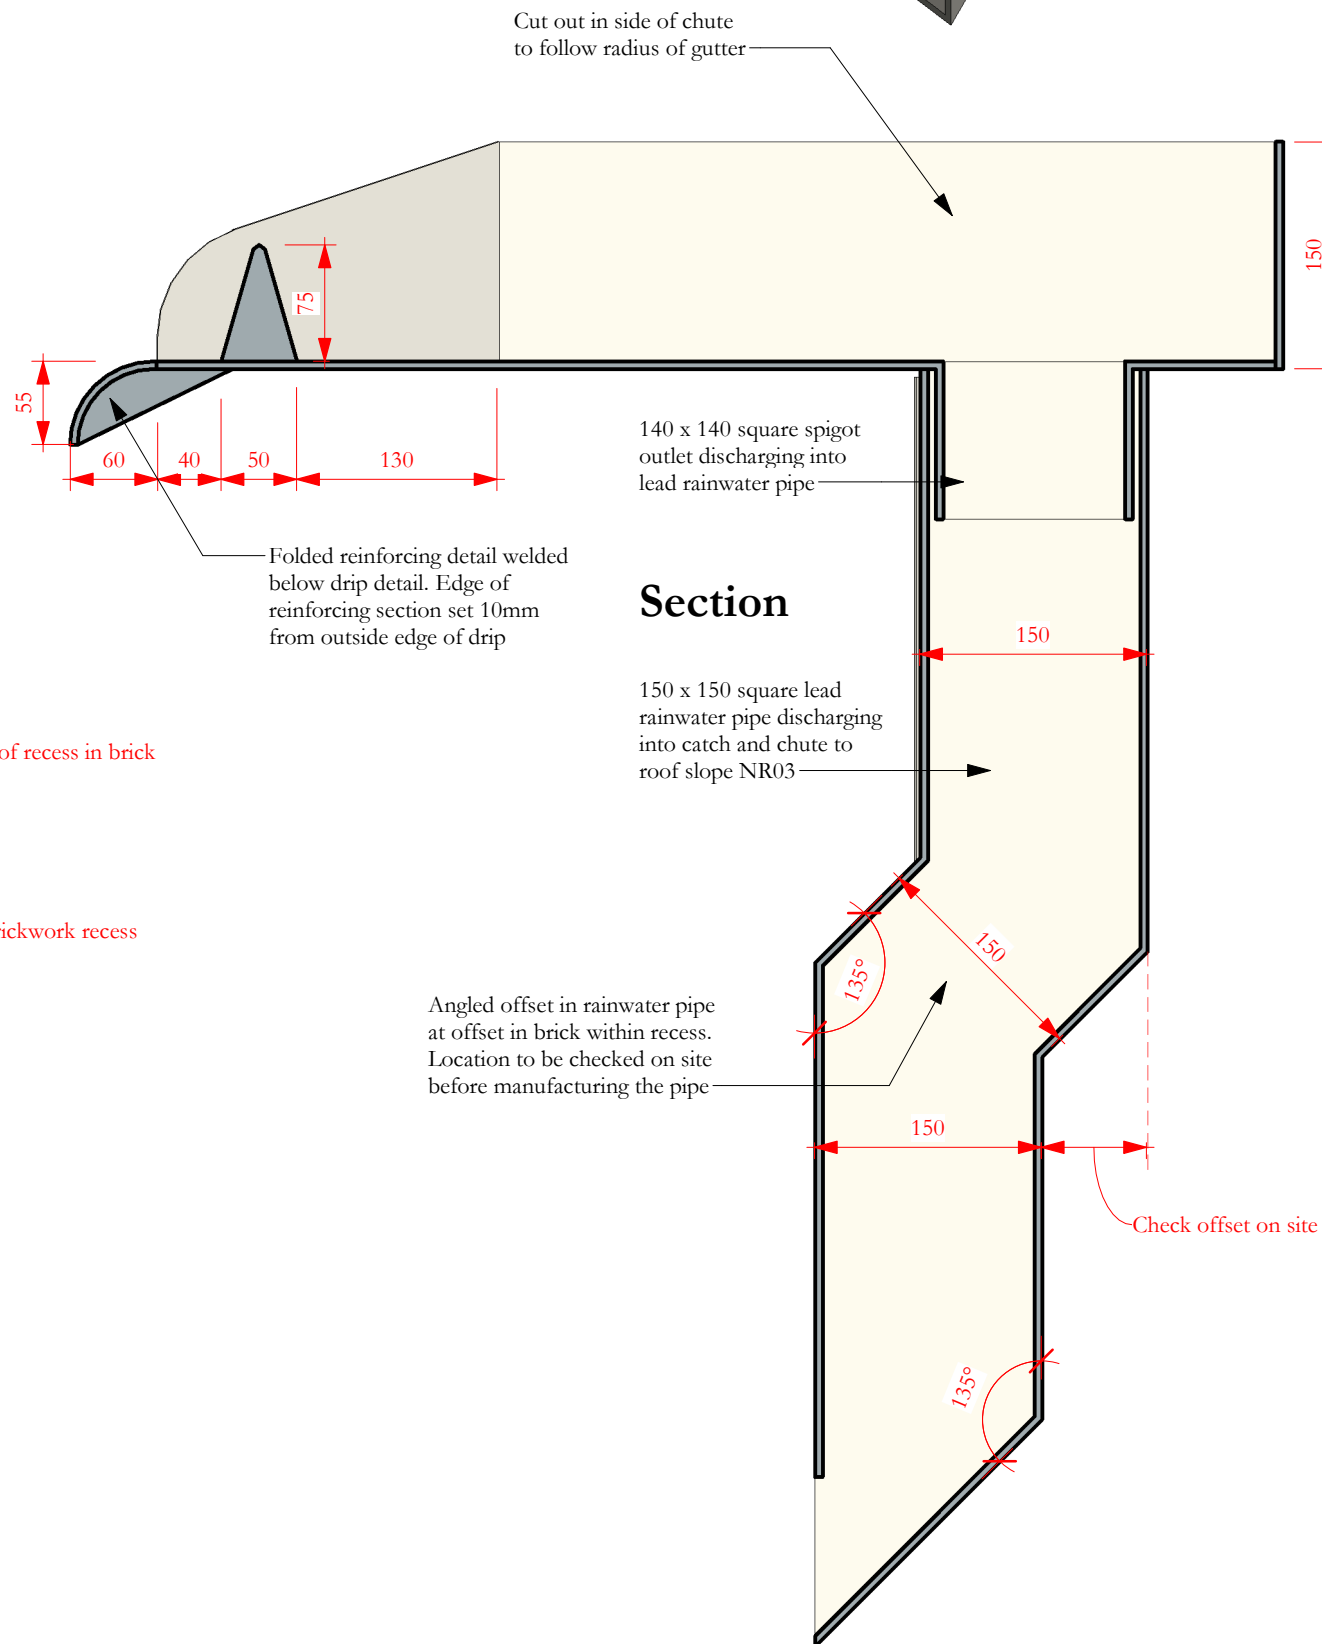

Revision 01: Curved cut out sections to sides of chute omitted. Fixing taps changed to fixing strip with allowance for cover over fixings instead of lead domes

22/07/2024	JC	GR	First issue
01	05/03/2025	JC	See note in revision cloud
ISSUE	DATE	APPROVED DRAWN	DESCRIPTION



OUR
TOWN
HALL
PROJECT



Project Office, Room 308, Town Hall, MANCHESTER M60 2L1
+44 (0) 7970 097 432
www.purcelluk.com

PROJECT STATUS **RIBA stage 5**

CLIENT **Manchester City Council**

PROJECT **Our Town Hall**

DRAWING TITLE **Lead chute to rainwater pipes RWP 27.1 and 28.2**

SIZE & SCALE **A2: 1 : 5**

DRAWING STATUS **S4 Construction**

JOB NUMBER **236959**

DRAWING NO. **OTH-PUR-TH-RF-DWG-A-7615 01** REV

© PURCELL 2019. PURCELL ® IS THE TRADING NAME OF PURCELL ARCHITECTURE LTD.