


CANDOPY LAYOUT
1:25@A1


KITCHEN LOCATION

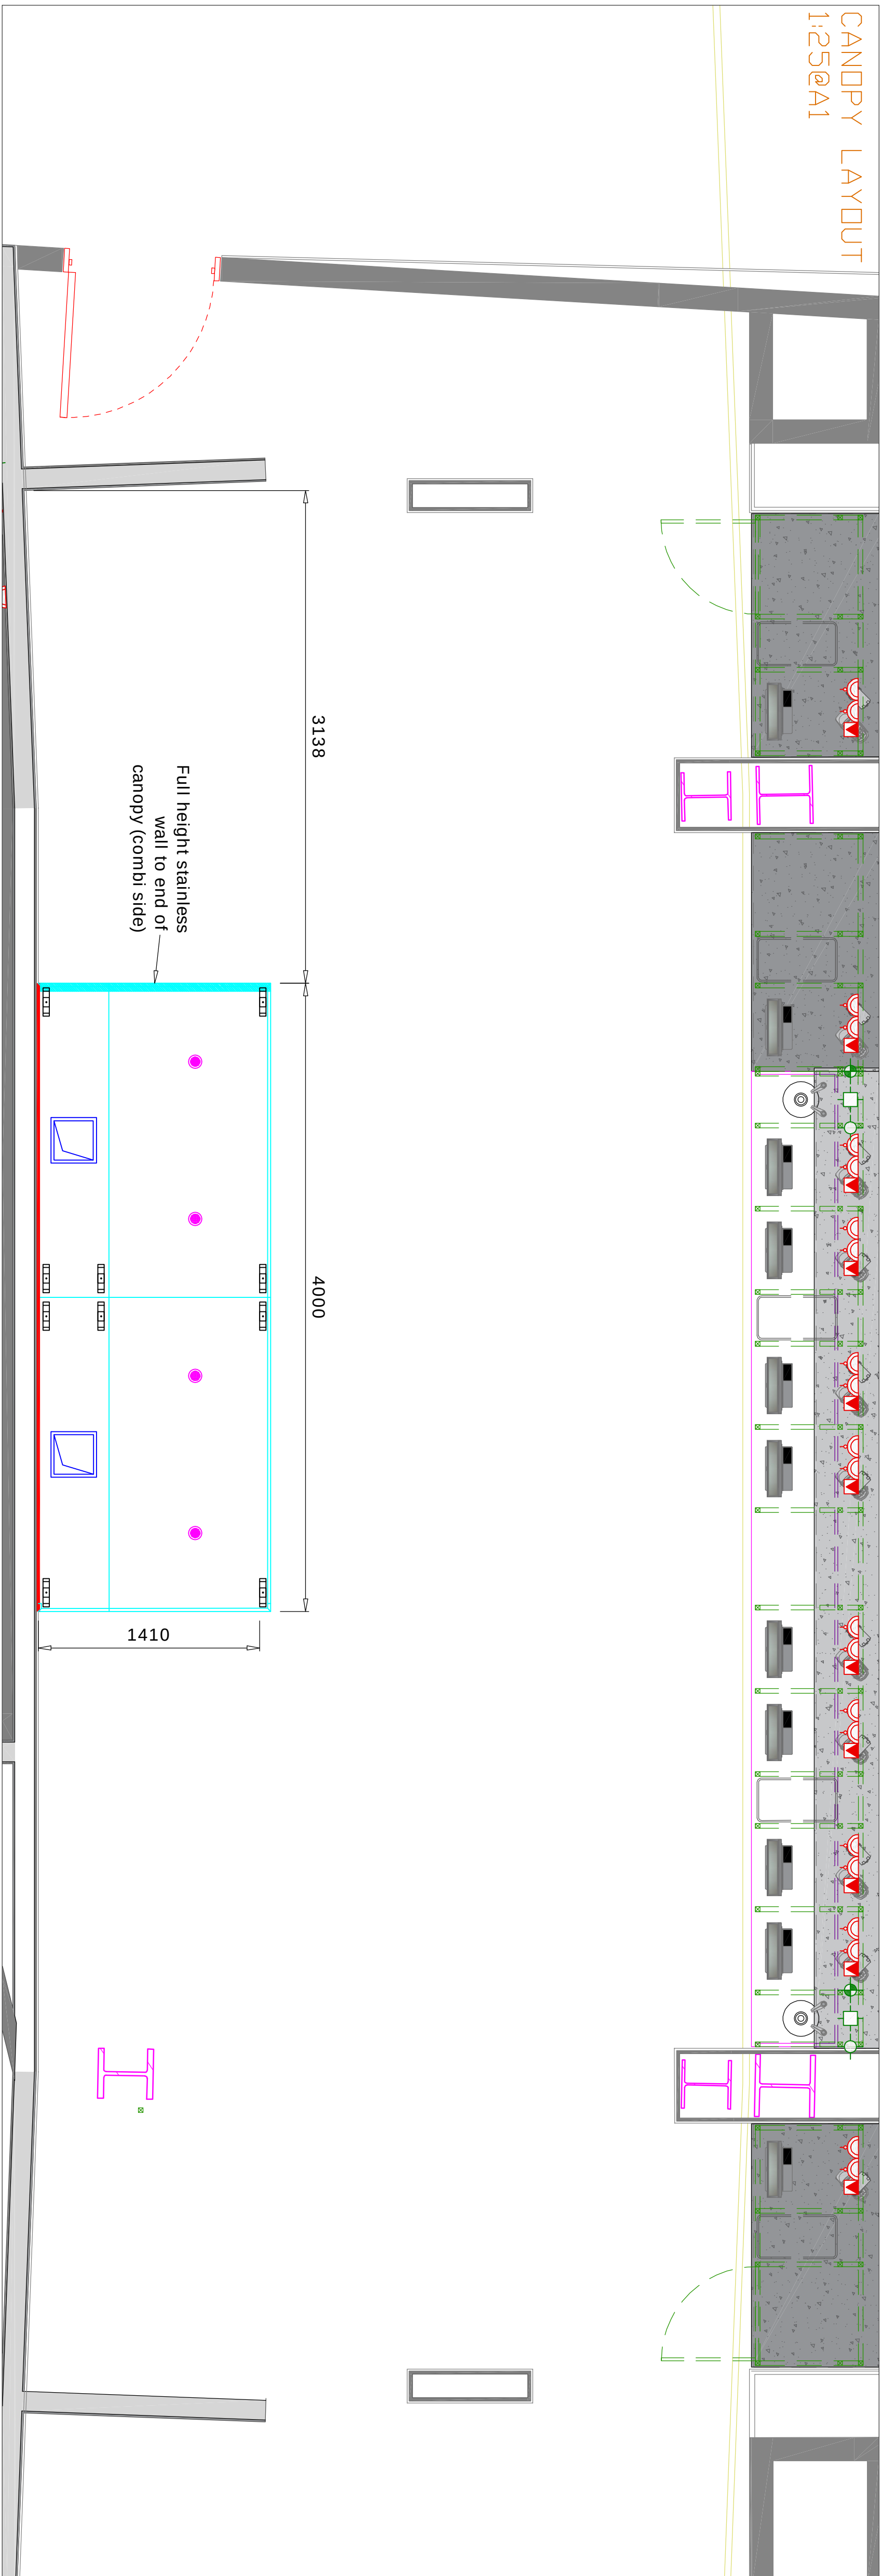


CANOPY INFORMATION

EXTRACT DUTY CANDY
400 X 140 X 500
2000 UNFINISHED OF CANDY FROM
FINISHED FLOOR LEVEL.
EXTRACT FLOW RATE 0.65 M³/S AT 100 PA
SPIGOTS ARE 80MM TALL WITH 20MM MEZ
CONNECTION
2 EXTRACT SPIGOTS @ 50K/250
SPIGOTS FIXED IN FACTORY- YES
NUMBER OF BAFFLE FILTERS- 80
LIGHTING- 4 0FT LED SPOT LIGHTS.
EACH LED LIGHT REQUIRES 240V SUPPLY
AND WILL BE SUPPLIED WITH A 15W TALL
CANDY
FINAL CONNECTION OF CANDY LIGHTS TO
ELECTRICAL CONTRACTOR 240V REQUIRED.
CLADDING- TO REAR
INFLU-S-FILL, HEIGHT STAINLESS WALL
TO ONE END OF CANDY 400MM TALL TO
TOP OF CANDY
CANDY APPROVED- YES...../NO.....
COMMENTS.....
SIGNED.....
DATE.....


FRONT ELEVATION
1:25@A1

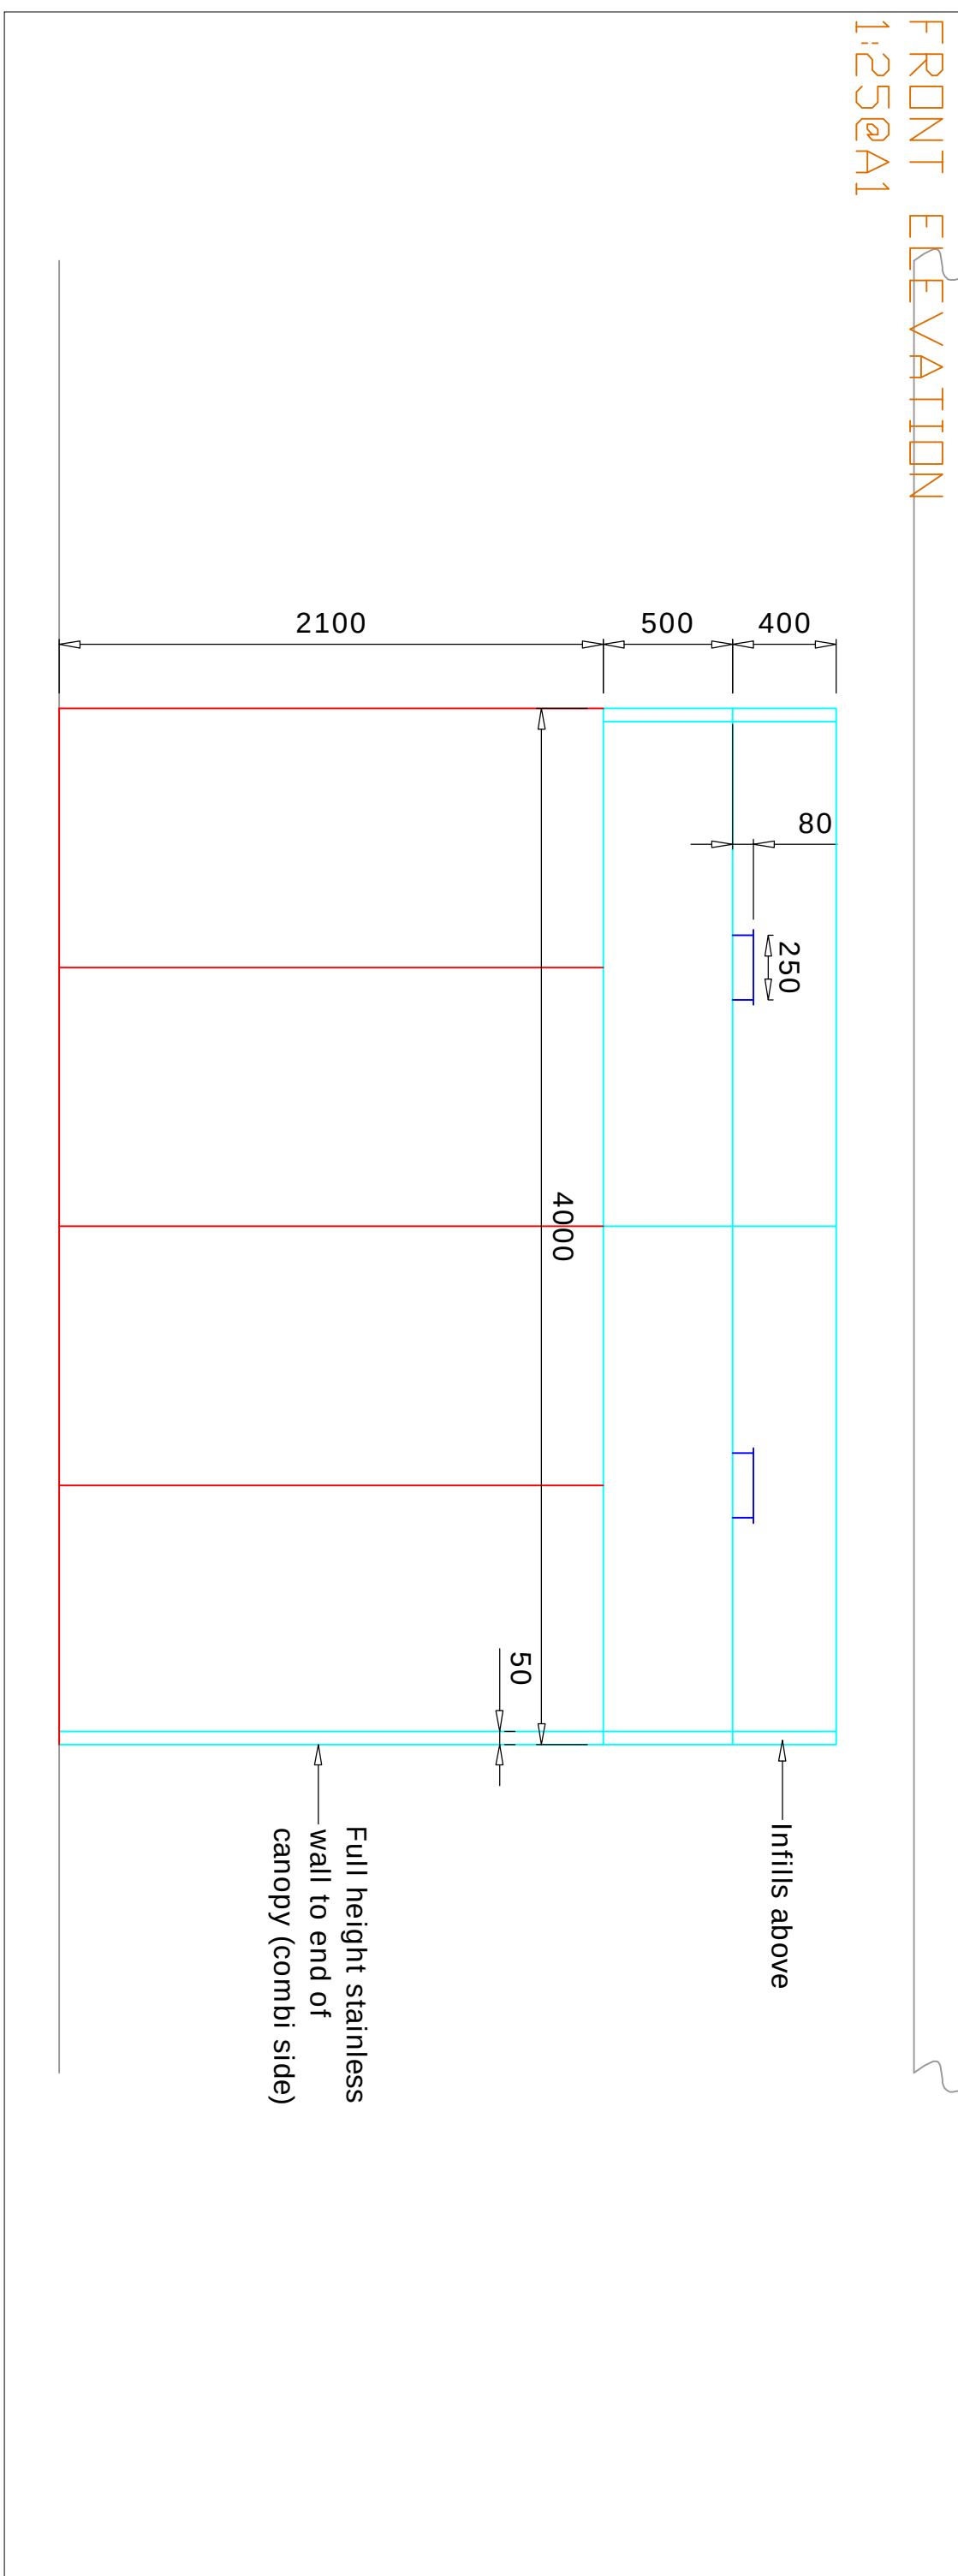


CANDPY CROSS SECTION
1:25@A1

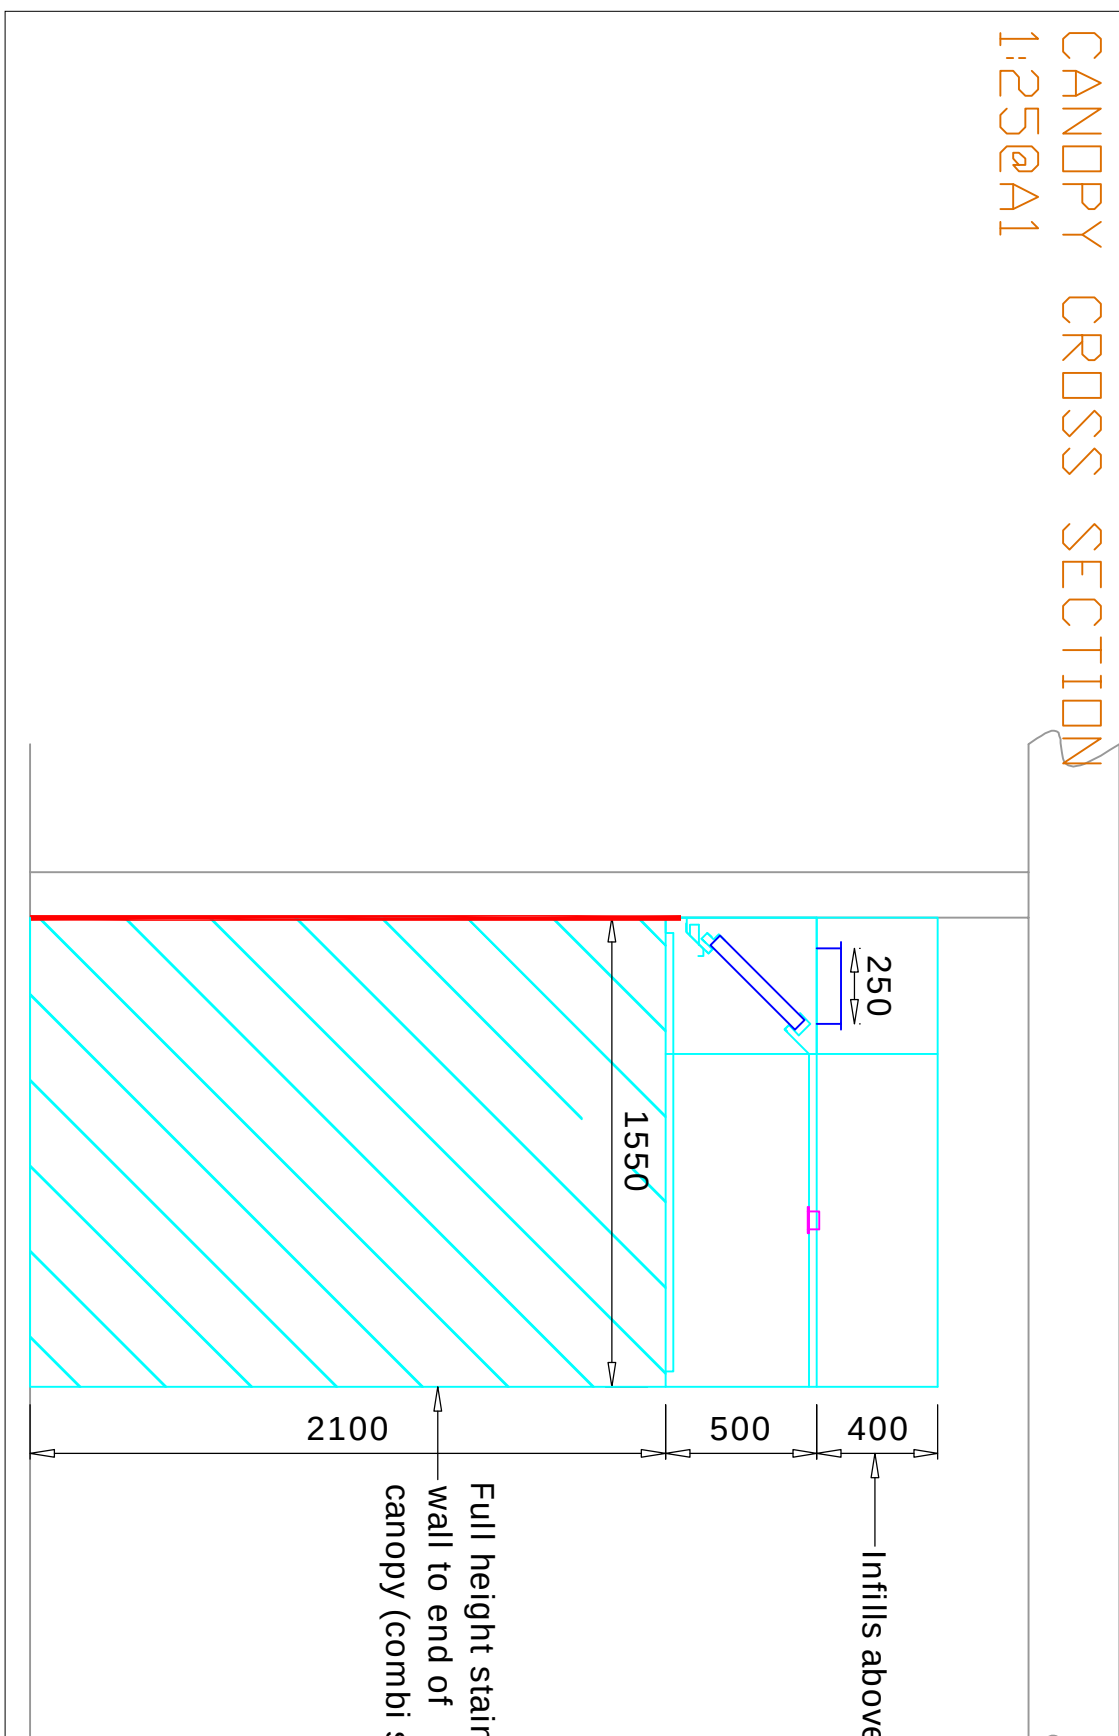

CANOPY/SPIGOT DIMENSIONS
1:50@A1

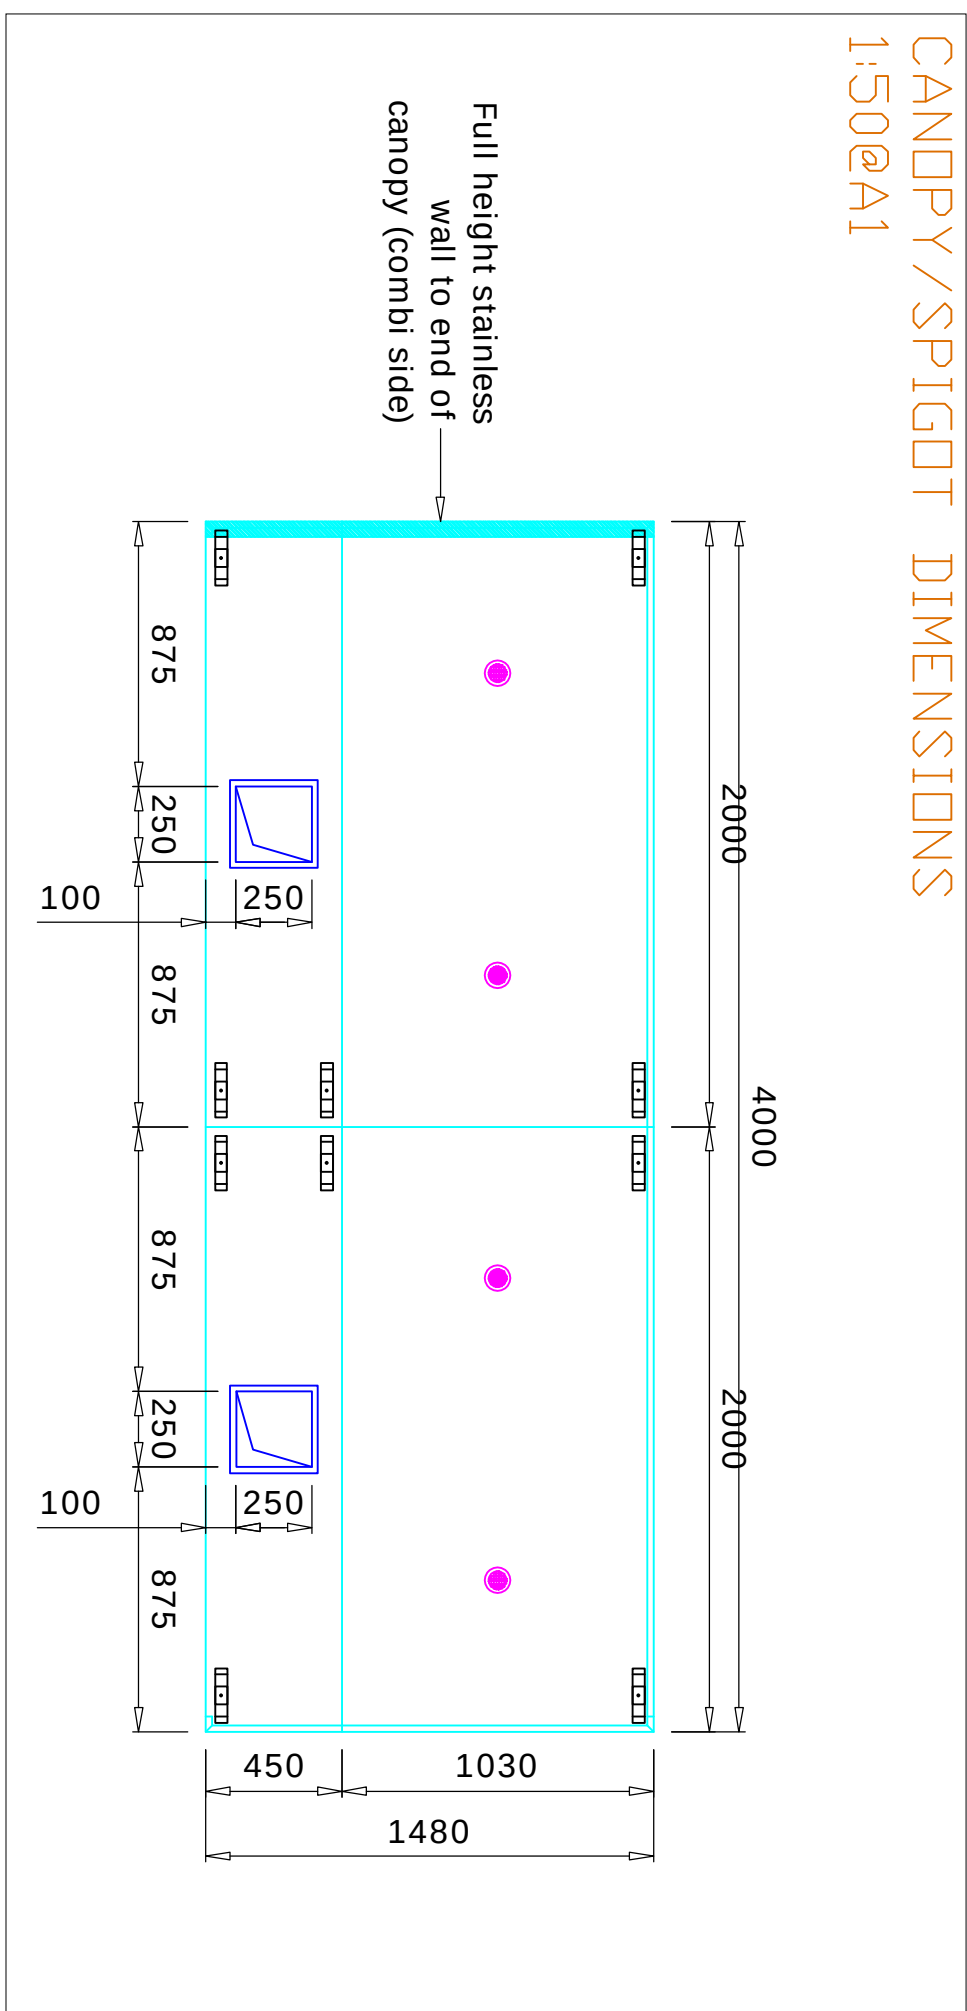

CANDY OVERHANGS
1:25@A1

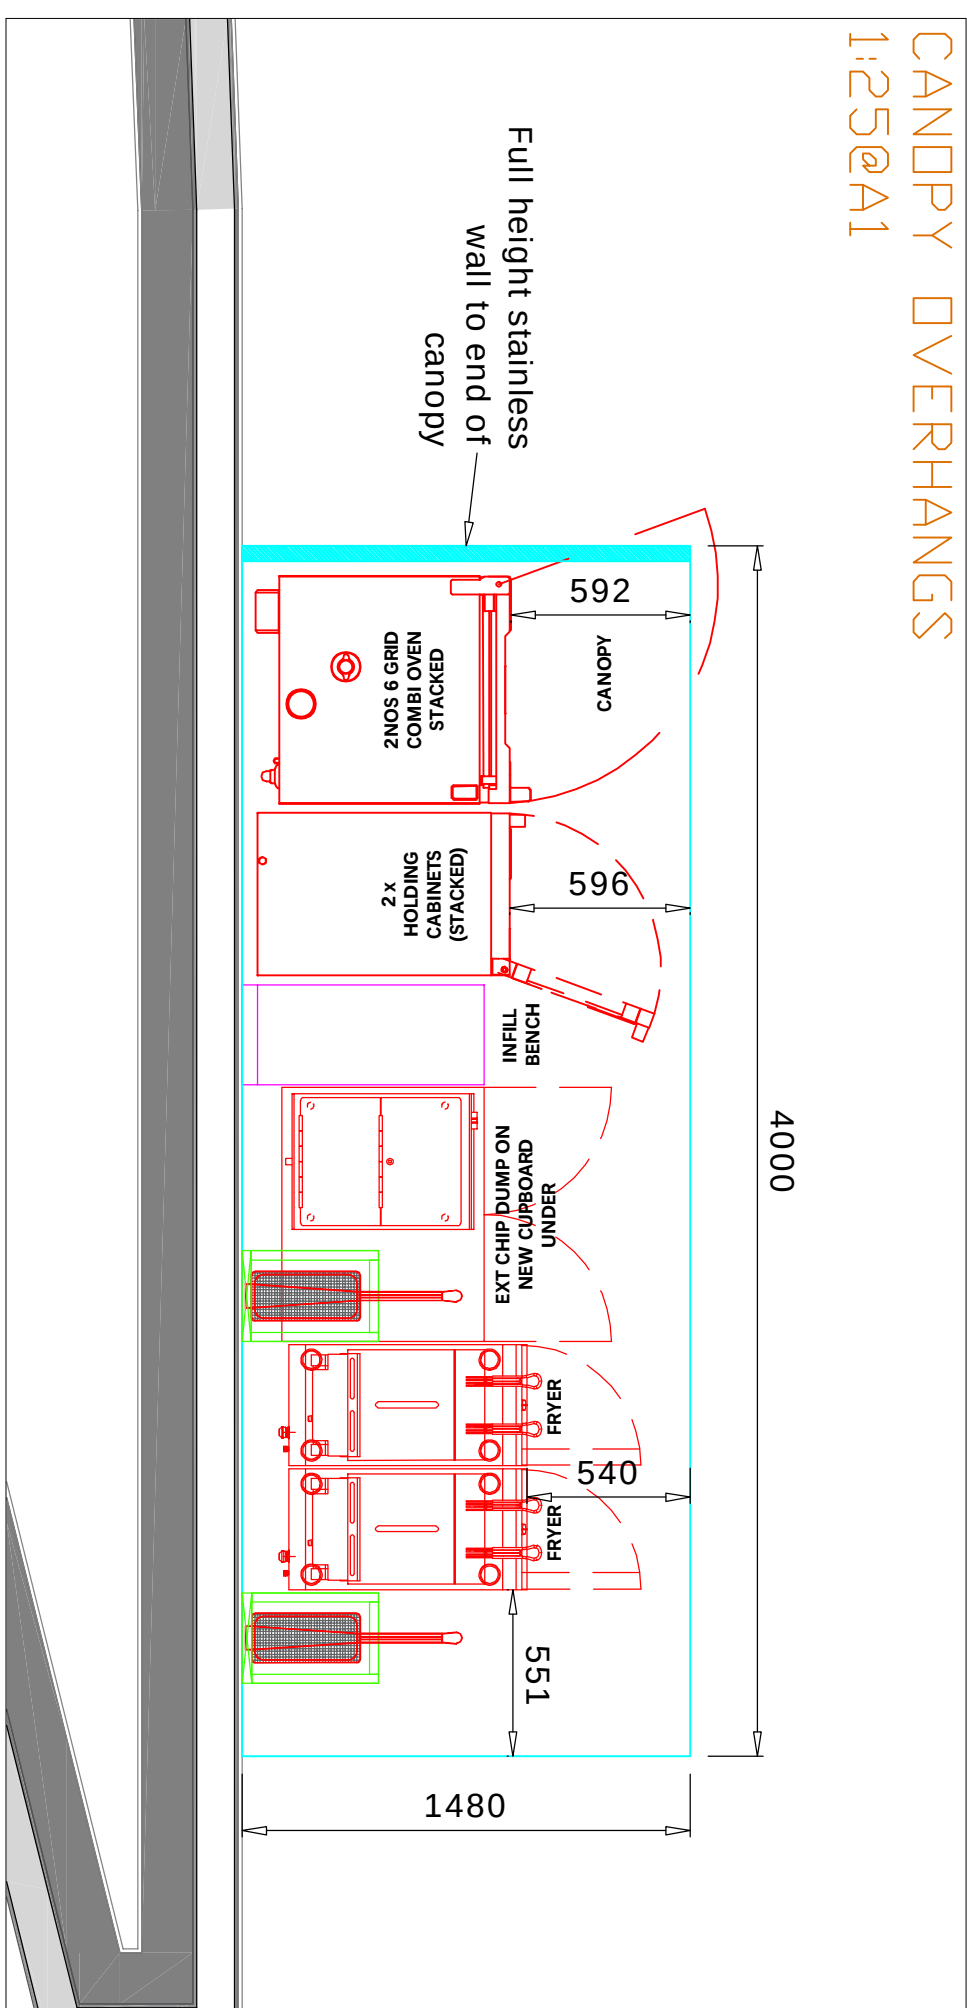

CANOPY AIRFLOW CALCS

Leightec Thermal Convection Airflow Calculation																					
In Accordance With BEFA Specification/DW-2018																					
Project	MCFC				Date																
Drawing	CONCESSION -5/6				Canopy Ref	ITEM 14															
Model	Wall - Open One End	<table><tr><td>Safety Factor</td><td colspan="4">0%</td></tr><tr><td>Extract Volume</td><td colspan="4">0.65 m³/S</td></tr><tr><td>Supply Volume</td><td colspan="4">0.55 m³/S</td></tr></table>					Safety Factor	0%				Extract Volume	0.65 m³/S				Supply Volume	0.55 m³/S			
		Safety Factor	0%																		
		Extract Volume	0.65 m³/S																		
Supply Volume	0.55 m³/S																				
Item	Description	Width	Depth	Power	Coefficient	Gas kW	Sub total														
0	Combination Ovens 6 grid.	752	765	Electric	0.3	0	0.172586														
0	Holding Oven	538	834	Electric	0.1	0	0.044669														
0	Chip Soakline	450	620	Electric	0.15	0	0.0405														
0	Deep Fat Fryer	400	786	Electric	0.45	0	0.14748														
0	Deep Fat Fryer	400	766	Electric	0.45	0	0.14438														

CLIENT	MFCF
PROJECT	NORTH STAND EXTENSION
TITLE	NS-101-CLUB LEVEL CONCESSIONS 5
DWG NO	NSC-0MM-NS-01-0P-X-001012
REVISION	C01
STATUS	A5
SCALE	1:25
DRAWN BY	CDJ
CHECKED BY	C J
DATE	05.09.2002
PAPER SIZE	A1
APPROVED BY	

DAWNVALE GROUP
RESTAURANT + BAR DESIGN + BUILD

UNITS 1 & 2 ALBERT STREET | HOLLINWOOD OLDAHAM OL10 3P
TEL: 0145 664 7879 DAWNWALDCOM

COPYRIGHT © 2017

THE INFORMATION ON THIS DAWNING IS THE SOLE COPYRIGHT OF DAWNWALDCOM AND MAY NOT BE COPIED OR REPRODUCED WITHOUT PRIOR WRITTEN CONSENT. ALL RIGHTS RESERVED.

DISCLAIMER

DAWNING IS ATTENDED FOR ALL THE PURPOSES ONLY. IT MAY BE USED TO BE ASSURED WITH CLIENT. ALL DAWNING TO BE ASSURED WITH CLIENT. A MAJOR CHECKED AGAINST THE PRIOR TO MANUFACTURE.