
 
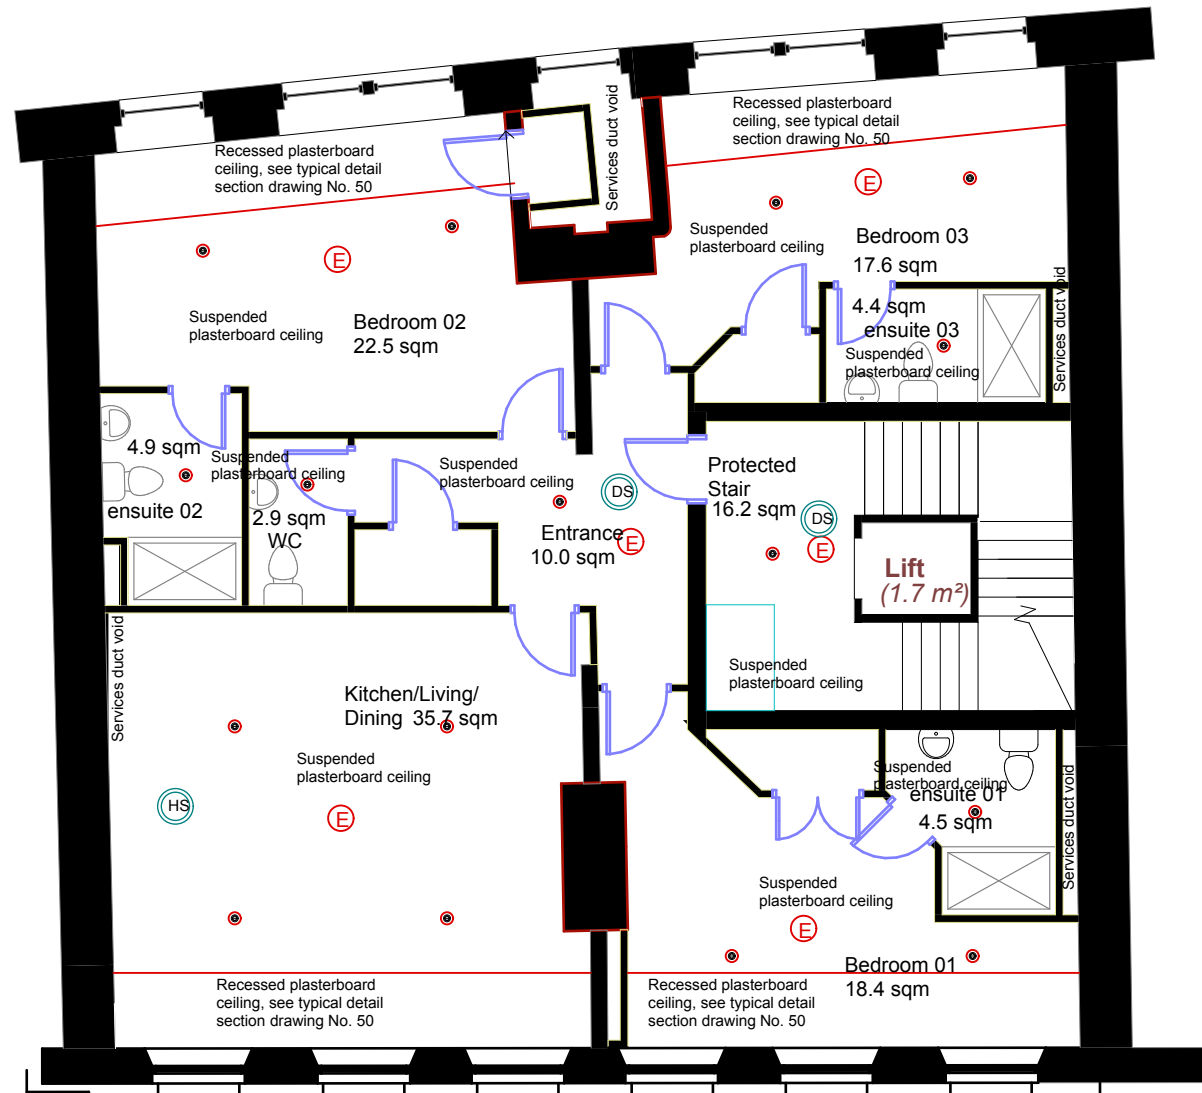




Proposed Third Floor Reflected Ceiling Plan

185 sqm

44-50 Portland street M1 4GS
Scale 1:100 Drawing No. 42

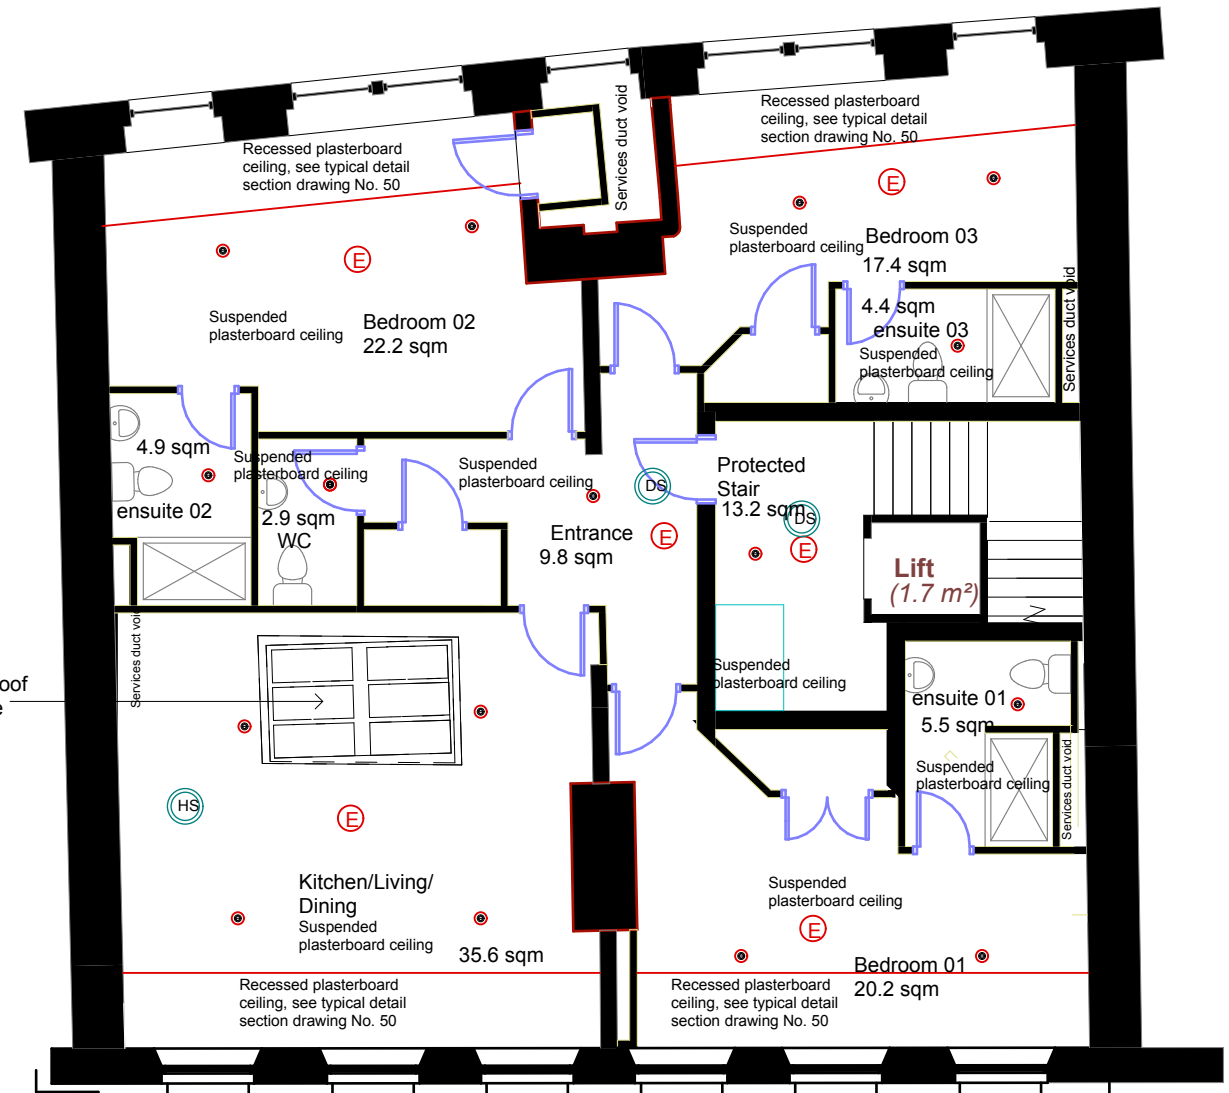

Proposed Fourth Floor Reflected Ceiling Plan

185 sqm

- LED recessed light
- Ⓢ Automatic smoke detector installed in accordance with BS 5839 linked alarm system
- Ⓜ Automatic Heat detector installed in accordance with BS 5839 linked alarm system
- Ⓢ Maintained emergency lights (3hr duration) fitted in accordance with BS 5266