
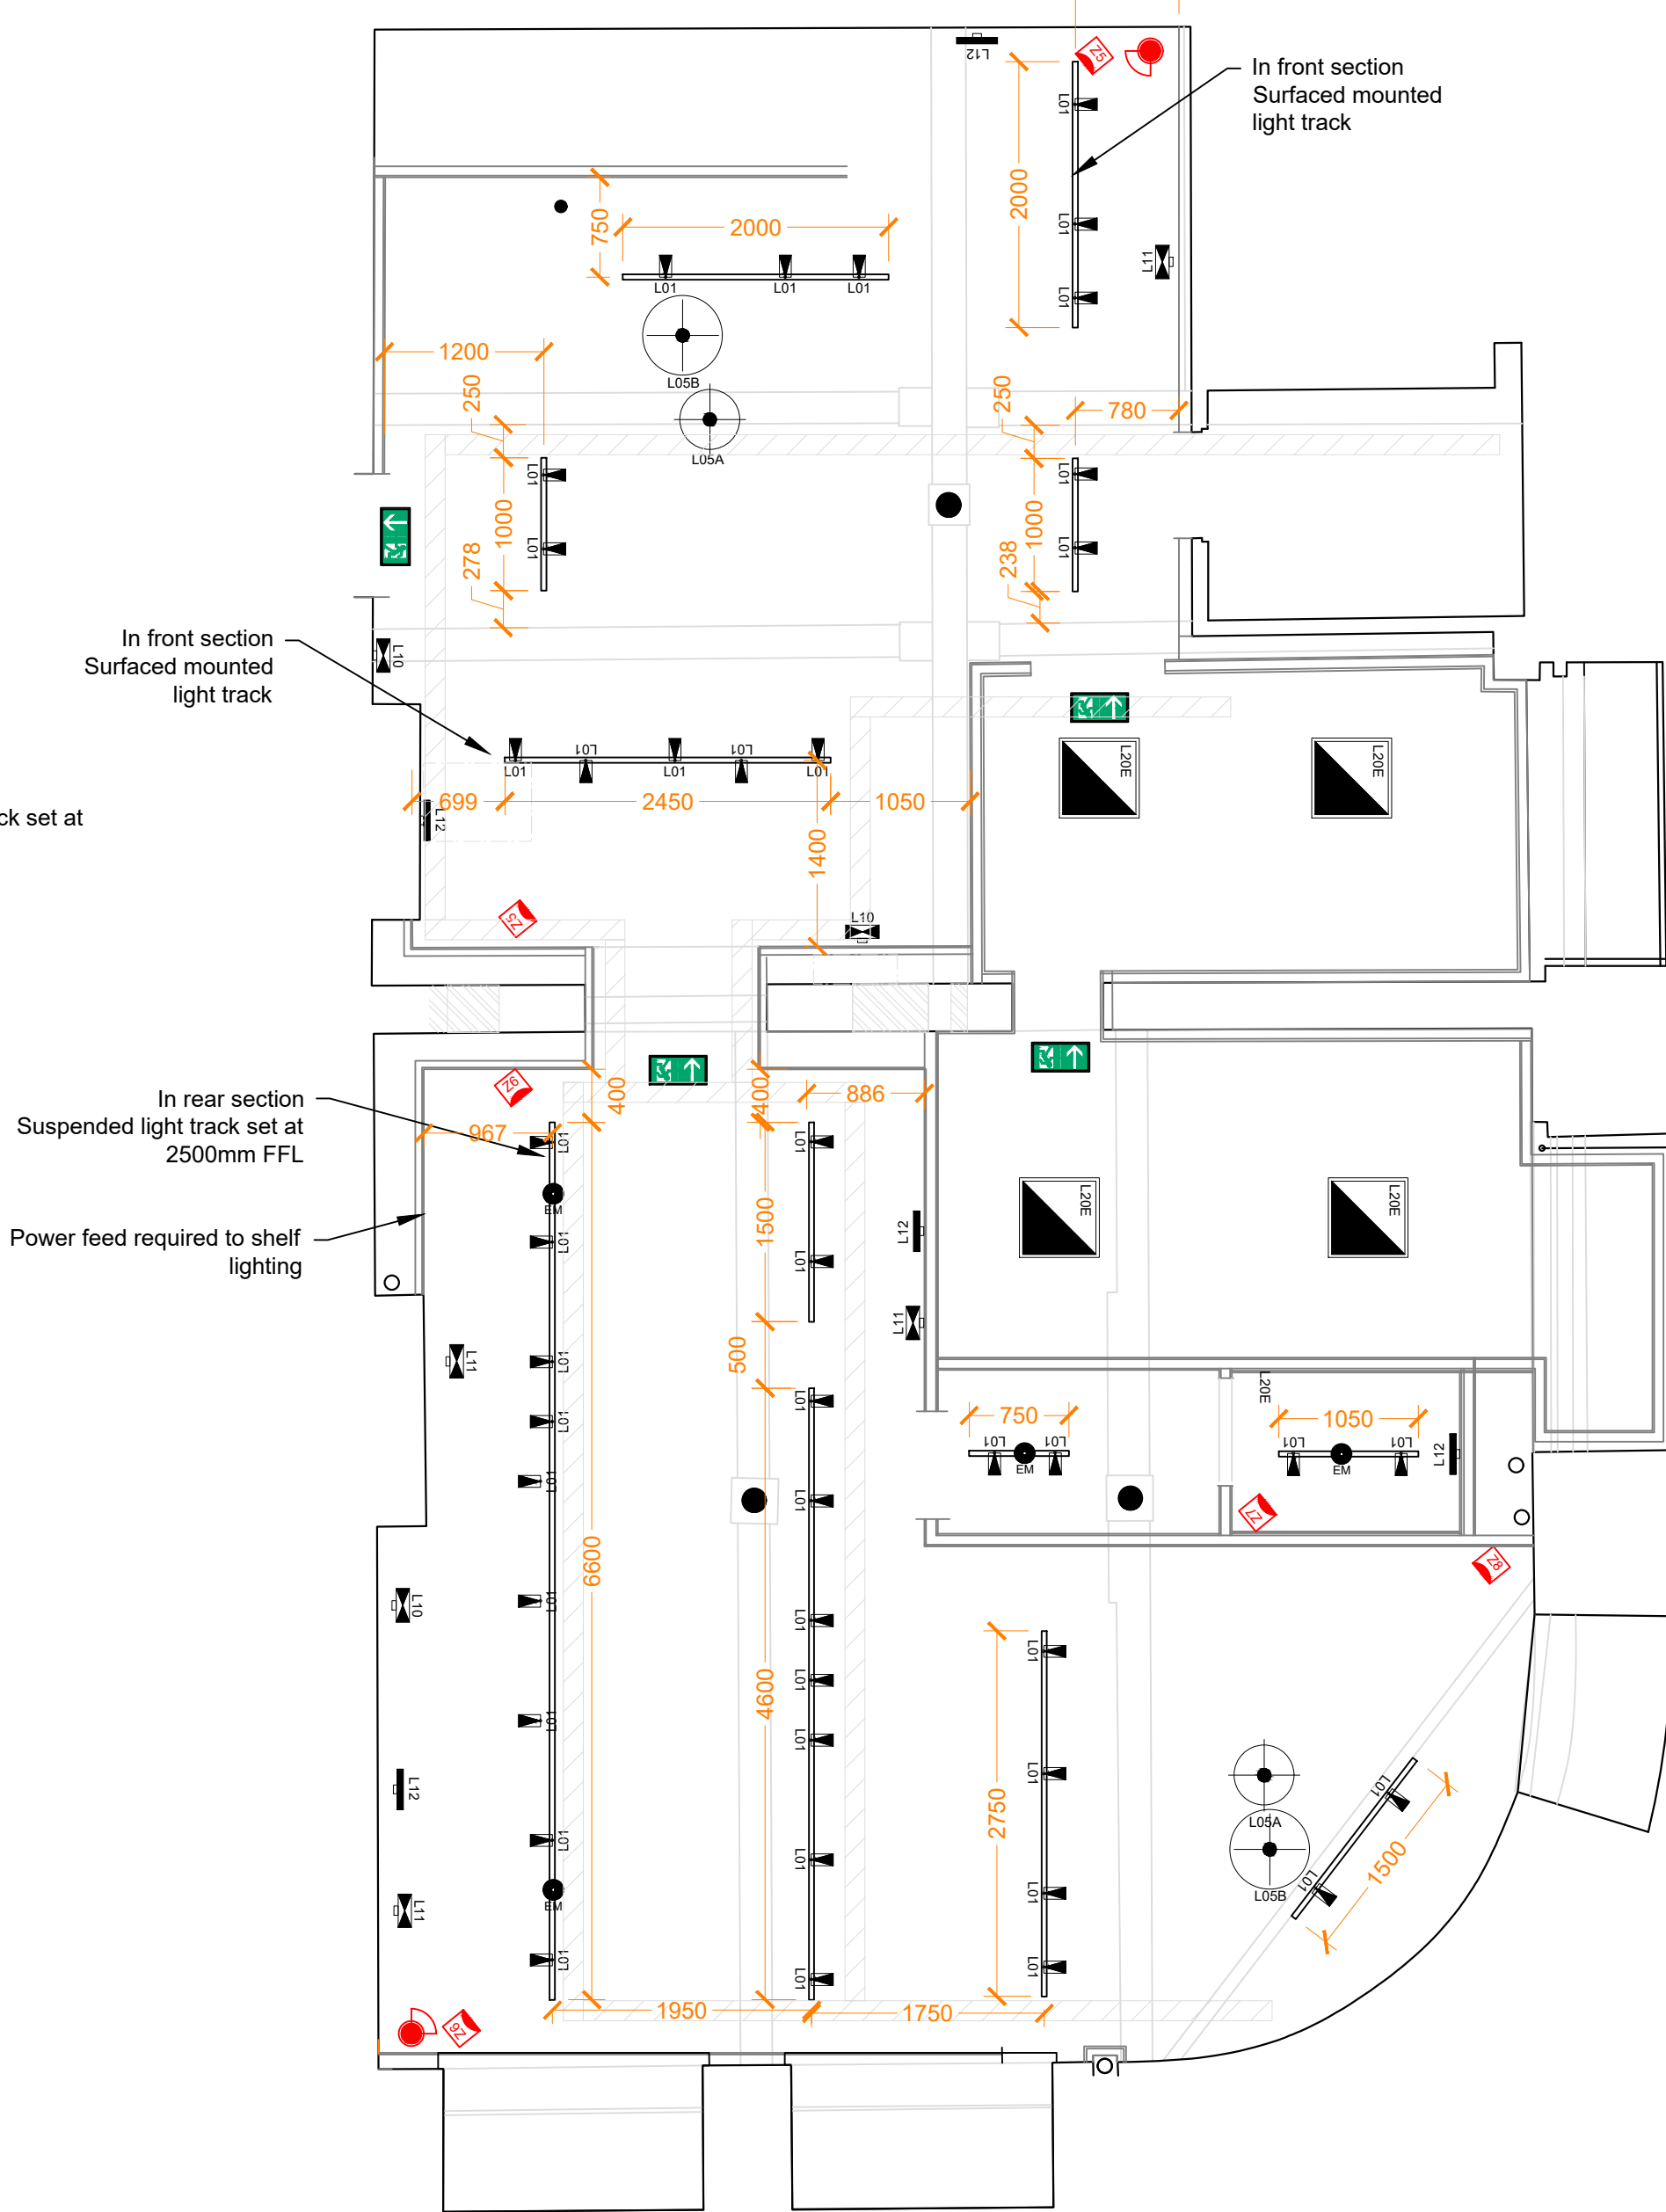


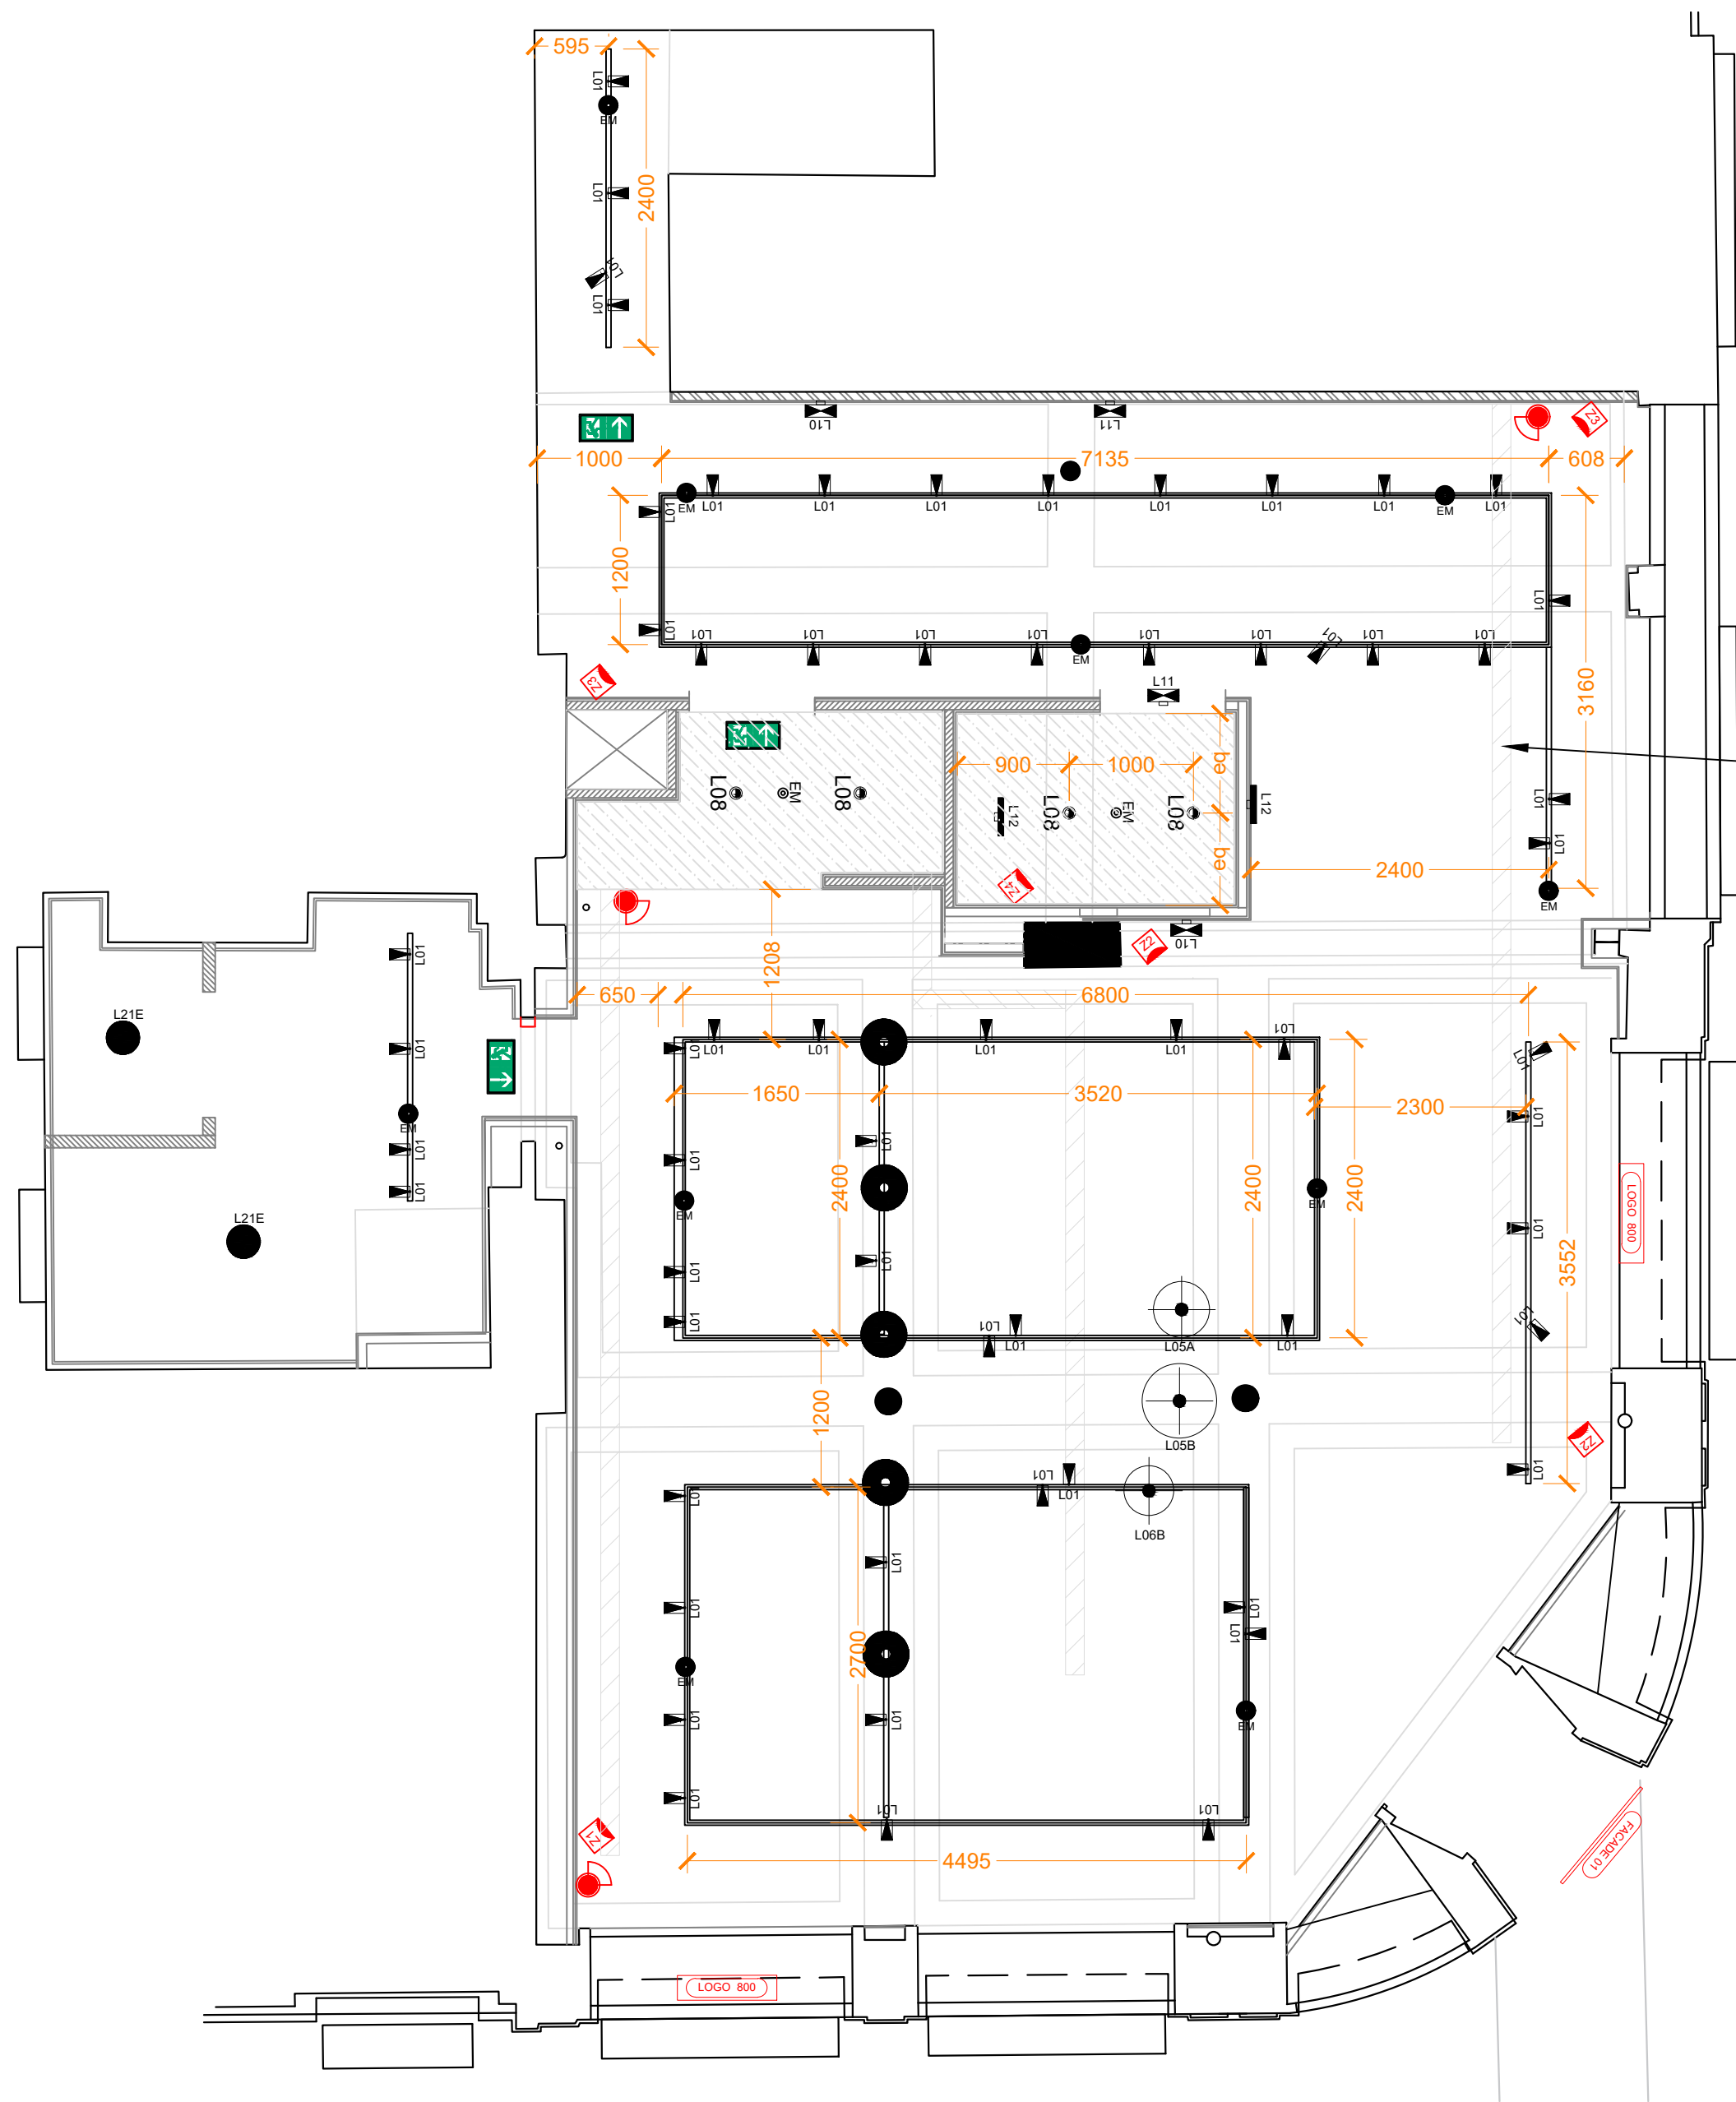

Lighting Controls
Store Room Controlled via PIR sensor . (contractor to position)
Cold / Freezer Room Controlled via PIR sensor . (contractor to position)
Window bed & Internal signage Controlled via dedicated timeclock
External Signage Controlled via dedicated timeclock
Track mounted including WC Controlled via last man out All on dimmer circuit Track spot light on circuit 1 Pendant lighting on circuit 2
Wall Lights Wall light on dimmer circuit controlled via last man out switch
Table Lights Controlled via last man out switch
Notes
Fire Alarm System L2 AFD system to be designed and installed in accordance with BS 5839 Part 1
Emergency Lighting New Emergency lighting to be designed and installed in accordance with BS 5266 Part 2 Table 9.
Fire Exit Signage New illuminated Fire Exit signage to be designed and installed in accordance with BS 5499 Part 1

03 Ground Floor | Reflected Ceiling Plan

Scale: 1:50@A1

03 Basement | Reflected Ceiling Plan

Scale: 1:50@A1

Symbol	Ref	Description	Mounting	Manufacturer / Ref	Size	Colour	Lamp	Dimmable	Wattage	Beam	Lumens	CRI	CCT	IP Rating	Weight	
	L01	LED Spotlight	Track	Illuma Concepta		White	LED	Yes	18w	36-38° (Medium)		90	3000K			
	L05A	Pendant	Suspended	Strand Ø45cm Closed by Muuto	Ø45cm x 35.4mm (H)	White	LED									
	L05B	Pendant	Suspended	Strand Ø60cm Closed by Muuto	Ø60cm x 54.8mm (H)	White	LED									
	L05C	Pendant	Suspended	Strand Ø80cm Closed by Muuto	Ø80cm x 60.8mm (H)	White	LED									
	L06A	Pendant	Suspended	Strand Ø28cm Open by Muuto	Ø28cm x 37.4mm (H)	White	LED									
	L06B	Pendant	Suspended	Strand Ø40cm Open by Muuto	Ø40cm x 50.2mm (H)	White	LED									
	L06C	Pendant	Suspended	Strand Ø60cm Open by Muuto	Ø60cm x 40.3mm (H)	White	LED									
	L08	LED Spotlight	Recessed	Illuma Infina		White	LED	Yes	18w	36° (Medium)		90	3000K			Remote Driver
	L10	Wall Light	Surface	Sasi Small by Nuura	155mm x 290mm	Brass	LED	Yes	11w	n/a	600	90	3000k		0.54 Kg	
	L11	Wall Light	Surface	Lila Medium by Nuura	Ø165 mm x 170mm	Brass / Opal	G9	Yes	17w	n/a	600	90	3000k		0.54 Kg	
	L12	Wall Light	Surface	Picture Light TBC	605mm x 200mm	Brass	G9	Yes	28w		450		2700K		1.6 kg	
	EM1	Emergency Light	Track	Illuma Emlux Duo	150 x 40	White	LED	n/a	1.5 w	125°	150	-	-	IP20	2.6kg	Intergal 3hr Non-maintained battery & driver
	EM2	Emergency Light	Recessed	Illuma Emlux Discrete	Ø45mm x 24.7mm	White	LED	n/a	1w	125°	150		4000K	IP20	0.15 kg	Intergal 3hr Non-maintained battery & driver
	ES1	EM Exit Sign	Surface	Illuma Emlux Surface	340 x 246	White	LED	No	2w			70	5700K	IP20	0.9kg	Intergal 3hr Non-maintained battery & driver
	ES2	EM Exit Sign	Track Mounted	Illuma Emlux Blade	340 x 246	White	LED	No	2w			70	5700K	IP20	0.9kg	Intergal 3hr Non-maintained battery & driver

Symbol	Ref	Description	Mounting	Manufacturer / Ref	Size	Colour	Lamp	Dimmable	Wattage	Beam	Lumens	CRI	CCT	IP Rating	Weight	
	L20	LED Slim Light Panel	Surface mounted	Contractor Choice	to fit 600x600 grid	White	LED	No	40w	120°	3700		3000K	IP20	1.8 kg	
	L20E	LED Slim Light Panel w/ EM pack / Battery	Surface mounted	Contractor Choice	to fit 600x600 grid	White	LED	No	40w	120°	3700		3000K	IP20	1.8 kg	Intergal 3hr Non-maintained battery & driver
	L21	Bulkhead Light	Surface mounted	Contractors Choice	330 x110	White	LED	No	12w		1050	70	4000K	IP65	1.2 kg	
	L21E	Bulkhead Light w/ EM Pack	Surface mounted	Contractors Choice	330 x110	White	LED	No	12w		1050	70	4000K	IP65	1.2 kg	Intergal 3hr Non-maintained battery & driver

REVISION	DATE	DETAILS
PROJECT		
77 Mosley Street Manchester		
JOE THE JUICE		
FLOOR		
Ground & Basement		
DRAWING TITLE		
Lighting Layout		
SCALE 1:50	PAPER SIZE A1	
DRAWING NUMBER 7042-03.2	REVISION G	
DRAWN BY SE	DATE March 25	
STATUS		
L1		
ad@designtime.com www.designtime.uk.com		
2-Work, 7 Cutter Mill Theyard North W61 1DY		